




Tungsten


**ROOF TILE - BRISTLE TUNGSTEN SMOOTH PROFILE**

Truffle

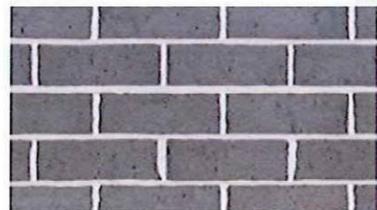

EXP

**PGH BRICK ALFRESCO TRUFFLE**  
Off White Mortar  
Ironged Joints

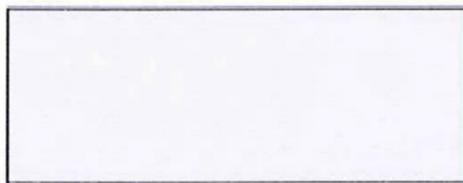


surf mist | matt  
NOT AVAILABLE IN VIC & SA


**TREND WINDOWS SURFMIST**



**DRIVEWAY- BLUESTONE PLAIN COLOUR**

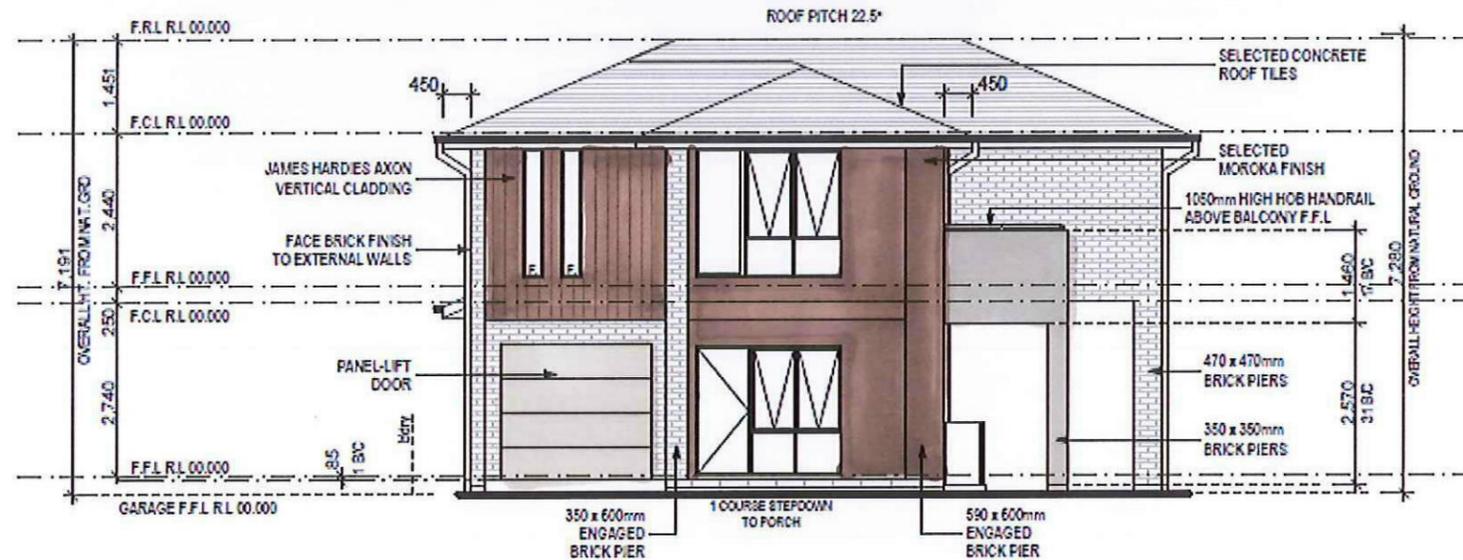

FRONT/SOUTH ELEVATION  
1:100

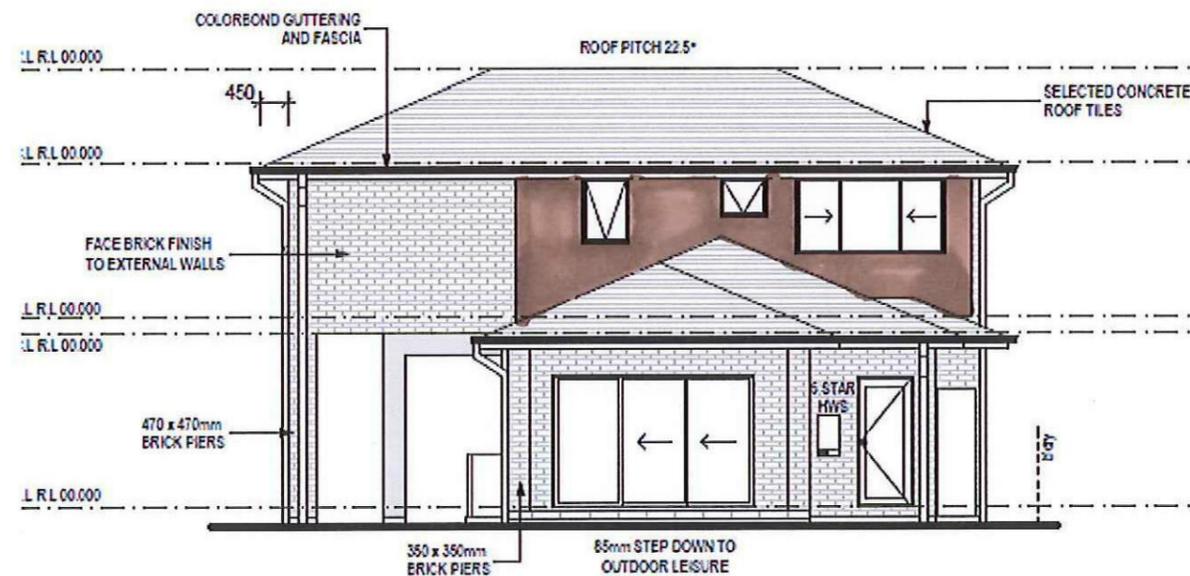

REAR/NORTH ELEVATION  
1:100

**COLORBOND - SURFMIST**


- FRONT DOOR
- GARAGE DOOR
- DOWNPIPES
- WATERTANK
- METERBOX
- BALCONY RAIL
- CEMENT RENDER TO BALCONY & PIERS

**COLORBOND - MONUMENT**


- GUTTER
- FASCIA

**BRISTOL PAINT**  
COBBLESTONE - CEMENT RENDER TO REMAINDER, BLUEBOARD AND CLADDING

	<b>PROJECT:</b> PROPOSED TWO-STOREY BRICK VENEER DWELLING	<b>JOB No:</b> 003530	<b>DRAWN:</b> DC
	<b>ADDRESS:</b> Lot 2355 William Hart Crescent Thornton Estate, Penrith	<b>LODGE MENT:</b> D.A/C.C	<b>DATE:</b> 25/02/14
<b>CLIENT:</b> Wisdom Homes Pty Ltd	<input checked="" type="checkbox"/> EXHAUST FAN <input checked="" type="checkbox"/> SMOKE DETECTOR, A3 3785-1993	<b>LGA:</b> PENRITH	<b>SITE CLASSIFICATION:</b> M' CLASS
Ph: 4647 1200 Fax: 4647 1233 www.wisdomhomes.com.au		<b>DESCRIPTION:</b> ABODE 27	<b>FACADE:</b> Classic
		<b>CODE:</b> WH-ABOD27D CL LH	<b>SHEET:</b> 5

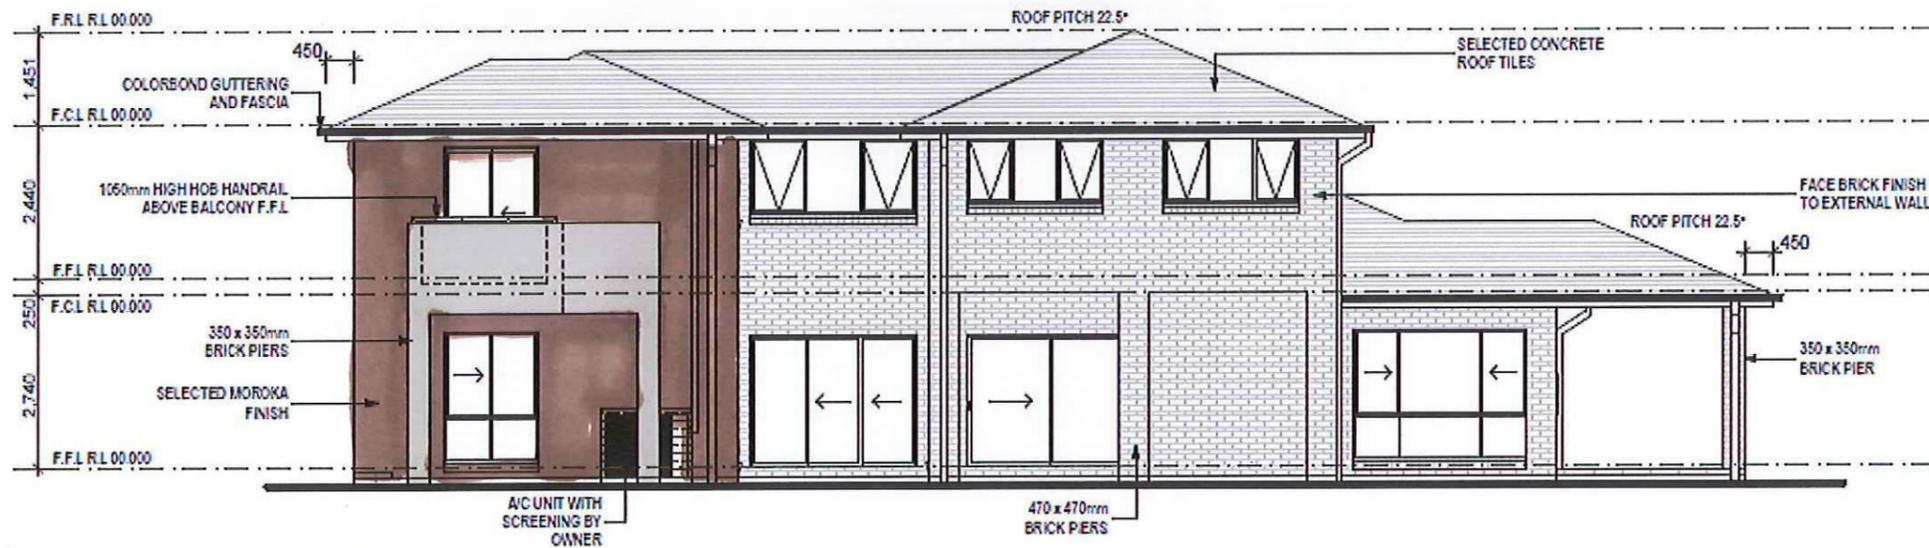

RIGHT/EAST ELEVATION  
1:100

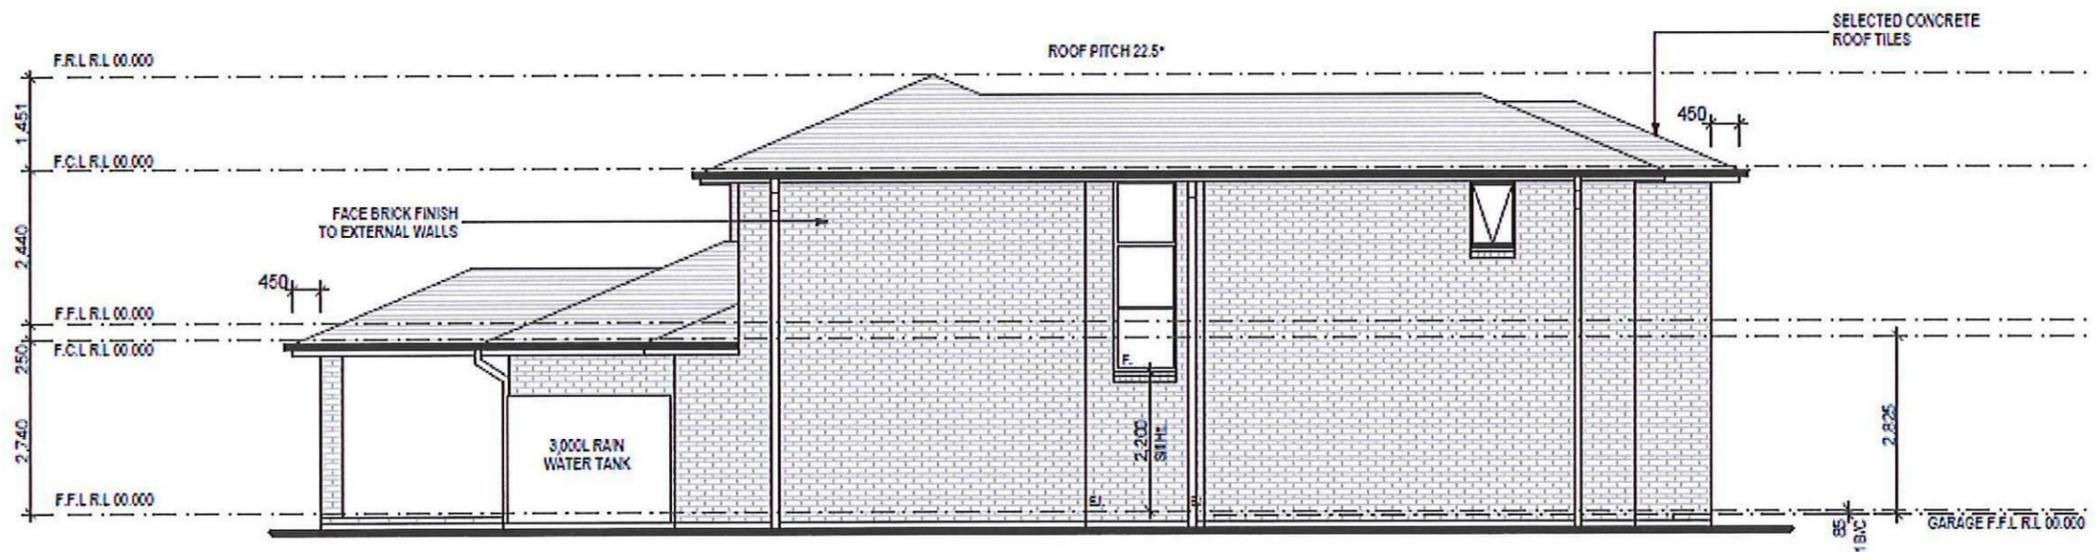

LEFT/WEST ELEVATION  
1:100

**NOTES:**  
REFER TO ENGINEERS DETAIL  
REFER TO ENGINEERS DETAIL  
LOCATIONS AND DIRECTIONS  
REFER TO FRUITS MANUFACTURE  
SPECIFICATIONS  
REFER TO A/C DETAILS FOR A/C

**Wisdom  
Smart**

Ph: 4647 1200 Fax: 4647 1233  
www.wisdomhomes.com.au

PROJECT:  
PROPOSED TWO-STORY BRICK VENEER DWELLING

ADDRESS:  
Lot 2355 William Hart Crescent  
Thornton Estate, Penrith

CLIENT:  
Wisdom Homes Pty Ltd

LODGE MENT:  
D.A/C.C

EXHAUST FAN  
 SMOKE DETECTOR. AD 3785-1993

JOB No:  
003530

DATE:  
25/02/14

LGA:  
PENRITH

DESCRIPTION:  
ABODE 27

CODE:  
WH-ABOD27D CL LH

DRAWN  
DC

SITE CLASSIFICATION  
M' CLASS

FAÇADE:  
Classic

SHEET:  
5

# Lot 2355 William Hart

## PLANT SCHEDULE Prepared by ecodeign Pty Ltd


SYMBOL	BOTANICAL NAME	COMMON NAME	QUANTITY	POT SIZE
<b>Aw</b>	Agapanthus 'White'	White Agapanthus	56	200mm
<b>Dg</b>	Dietes grandiflora	Wild Iris	7	200mm
<b>Fzk</b>	Fraxinus ornus 'Meczek'	Designer Flowering Ash	1	75L
<b>Gar</b>	Gardenia augusta 'Radicans'	Rock Gardenia	13	200mm
<b>Oi</b>	Ophiopogon 'Stripey White'	Stripey White Mondo Grass	9	200mm
<b>Vo</b>	Viburnum odoratissimum	Sweet Viburnum	17	300mm
<b>Vh</b>	Viola hederacea	Native Violet	26	150mm

### LOT PLANTING SUMMARY


Total Plants	Total Fence Hedging	Street Planting	Other Shrubs/ground-covers	Total Trees
129	17	56	56	1

**LEGEND**


- Proposed trees - refer to plant schedule
- Proposed accents & grasses - refer to plant schedule
- Existing tree to be retained
- Existing tree to be removed
- Proposed shrubs - refer to plant schedule
- Proposed groundcovers and grasses - refer to plant schedule
- Existing levels
- Proposed levels
- Existing levels
- Proposed levels
- Proposed Top Of Wall levels
- Boundary
- Garden edging
- Masonry retaining walls
- Existing contours

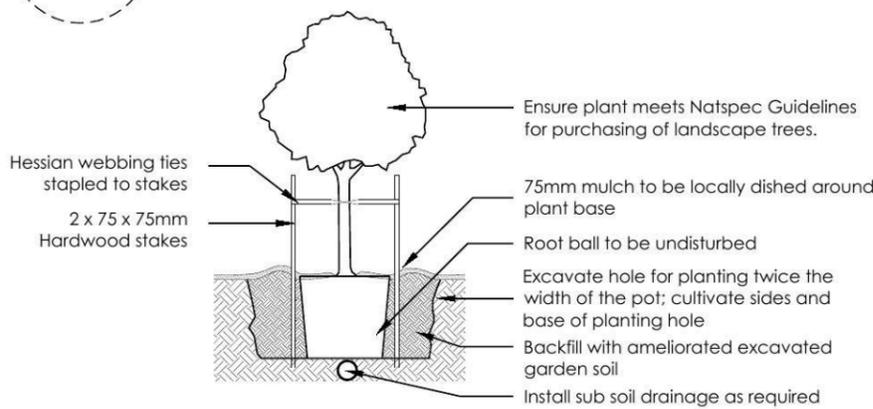


**1 Tree Planting Detail**  
NTS 25L - 100L Pot Size

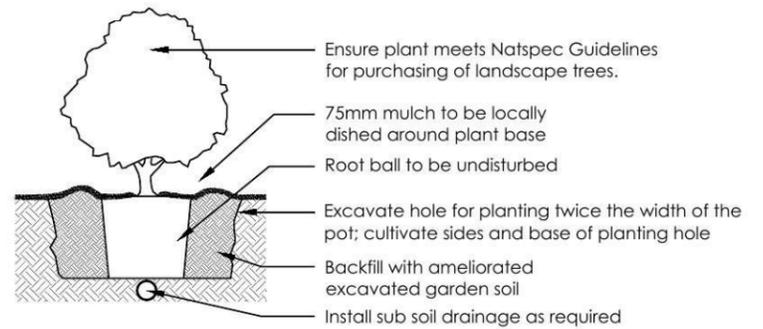

**2 Planting Detail**  
NTS 150mm, 200mm Pot Size

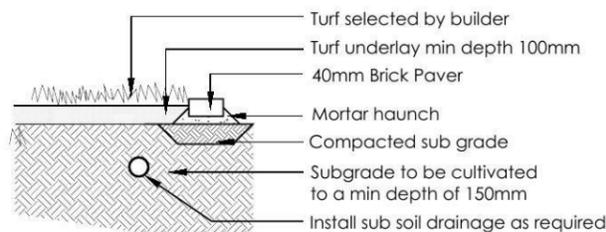

**3 Turf Detail**  
NTS Brick Paver Edge

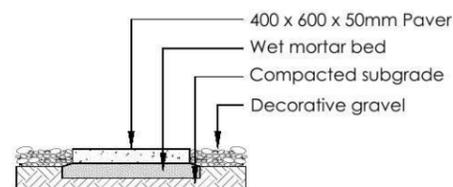

**4 Stepping stones in gravel**  
NTS Low traffic zone

REVISION	DESCRIPTION	DRAWN	CHECK	DATE
A	ISSUE FOR CLIENT REVIEW	RS	BT	17-03-14
B	AMEND DIMENSION TO WIR. ISSUE TO URBANGROWTH	RS	RS	18-03-14
C	ADD STREET PLANTING ALONG TYPE 2A FENCING	RS	RS	18-03-14
D	ADD SUB-STATION	RS	RS	20-03-14
E	CHANGE STUDY TO BED 4 REQUESTED BY URBANGROWTH	RS	RS	17-04-14
F	AMEND FRONT FENCE TO TYPE 1B	RS	RS	23-05-14
G	UPDATE ARCHITECTURALS + RE-ISSUE DA PLANS	RS	RS	04-09-14

**ecodeign**  
outdoor living environments

PO Box 8136, Boultham Hills BC, NSW 2153  
Ph: (02) 9680 7712 Fax: (02) 9680 7705  
Email: info@ecodeign.com.au  
Web: www.ecodeign.com.au  
Member of the Australian Institute of Landscape Designers and Mappers

1. Do not scale from drawings.  
2. Verify all measurements on site.  
3. Notify ecodeign of any inconsistencies.  
4. Copyright © ecodeign. All rights reserved.  
5. Drawing remains the property of ecodeign.

6. All work to comply with relevant Australian Standards or Building Code of Australia.  
7. All work to be performed by a suitably qualified tradesperson.  
8. For application purposes only - NOT FOR CONSTRUCTION.

ADDRESS: **LOT 2355 WILLIAM HART CRESCENT, PENRITH**

CLIENT: **WISDOM HOMES**


PROJECT: **NEW RESIDENCE**

DRAWING: **LANDSCAPE PLAN**


SCALE: **1:100 @ A3** DRAW: **DA** SHEET: **02**

DRAWN: **RS** CHECK: **RS** DATE: **04-09-14** REVISION: **G**



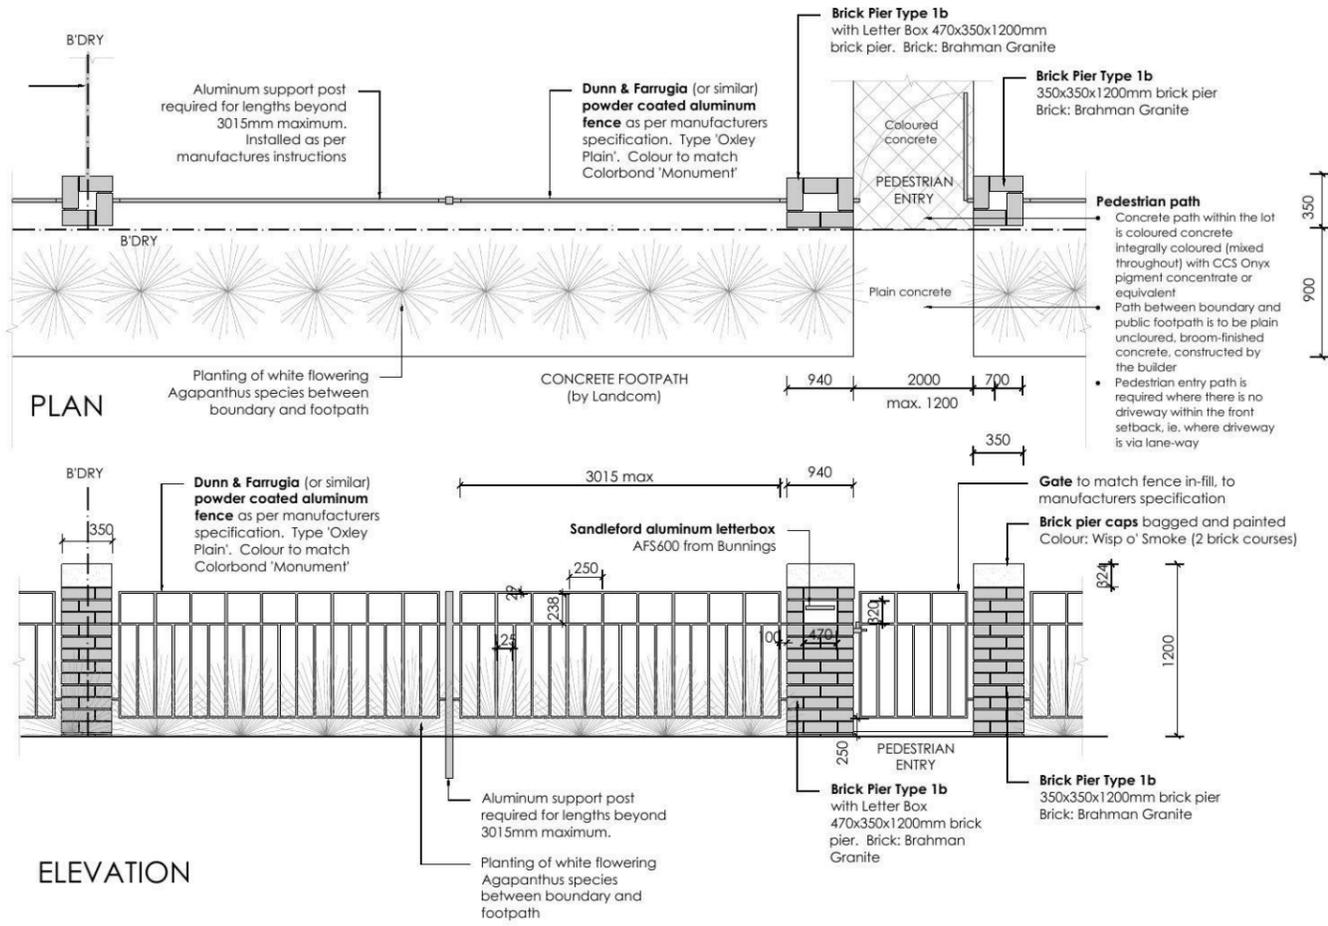

5 **FENCE TYPE 1b - Front Fence**  
1:50 Typical detail

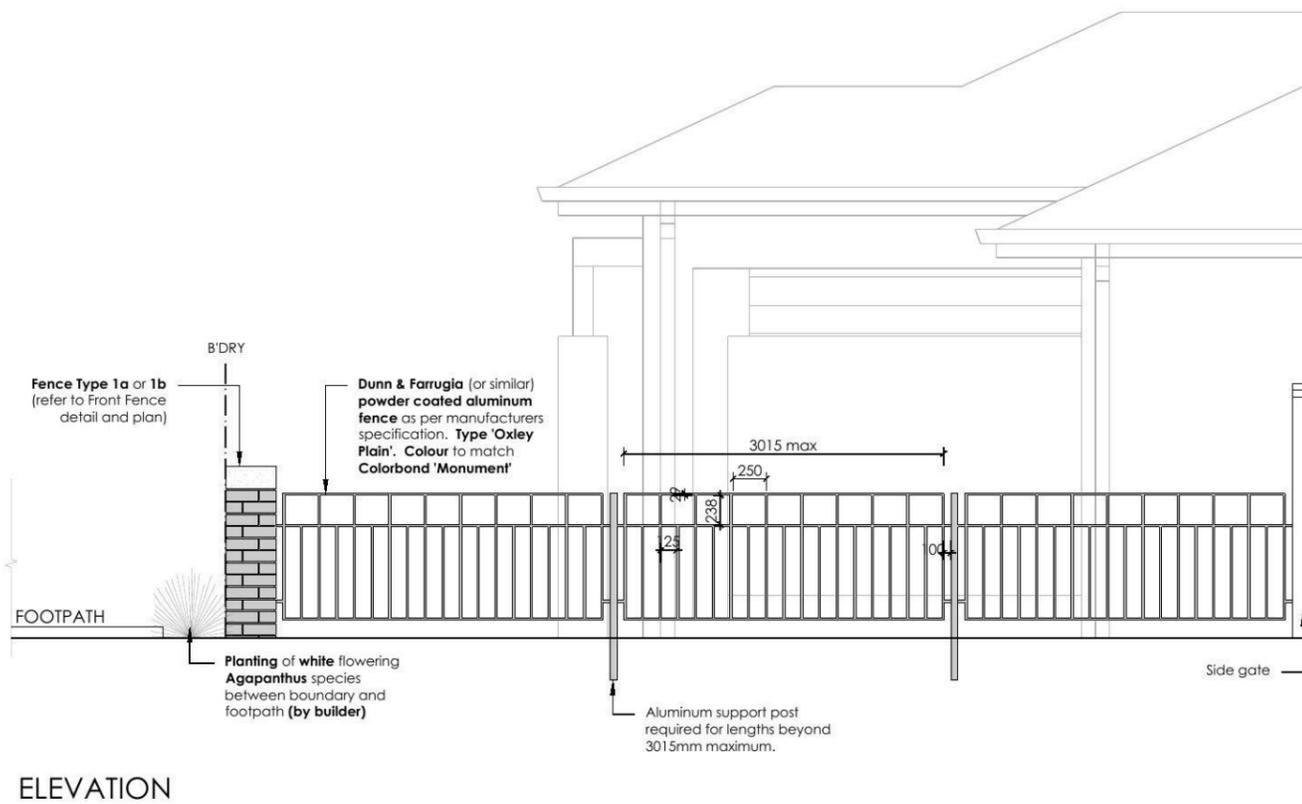

6 **FENCE TYPE 1c - Side Boundary Front Setback**  
1:50 Typical detail

REVISION	DESCRIPTION	DRAWN	CHECK	DATE
A	ISSUE FOR CLIENT REVIEW	RS	BT	17-03-14
B	AMEND DIMENSION TO WIR. ISSUE TO URBANGROWTH	RS	RS	18-03-14
C	ADD STREET PLANTING ALONG TYPE 2A FENCING	RS	RS	18-03-14
D	ADD SUB-STATION	RS	RS	20-03-14
E	CHANGE STUDY TO BED 4 REQUESTED BY URBANGROWTH	RS	RS	17-04-14
F	AMEND FRONT FENCE TO TYPE 1B	RS	RS	23-05-14
G	UPDATE ARCHITECTURALS + RE-ISSUE DA PLANS	RS	RS	04-09-14

**ecodesign**  
outdoor living environments

PO Box 8136, Boulkham Hills BC, NSW 2153  
Ph: (02) 9480 7712 Fax: (02) 9480 7705  
Email: info@ecodesign.com.au  
Web: www.ecodesign.com.au  
Member of the Australian Institute of Landscape Designers and Managers

1. Do not scale from drawings.  
2. Verify all measurements on site.  
3. Notify ecodesign of any inconsistencies.  
4. Copyright © ecodesign. All rights reserved.  
5. Drawing remains the property of ecodesign.

6. All work to comply with relevant Australian Standards or Building Code of Australia.  
7. All work to be performed by a suitably qualified tradesperson.  
8. For application purposes only - NOT FOR CONSTRUCTION

ADDRESS: **LOT 2355 WILLIAM HART CRESCENT, PENRITH**

CLIENT: **WISDOM HOMES**


PROJECT: **NEW RESIDENCE**

DRAWING: **LANDSCAPE PLAN**

SCALE: **1:100 @ A3** DATE: **DA** SHEET: **03**

DRAWN: **RS** CHECK: **RS** DATE: **04-09-14** REVISION: **G**



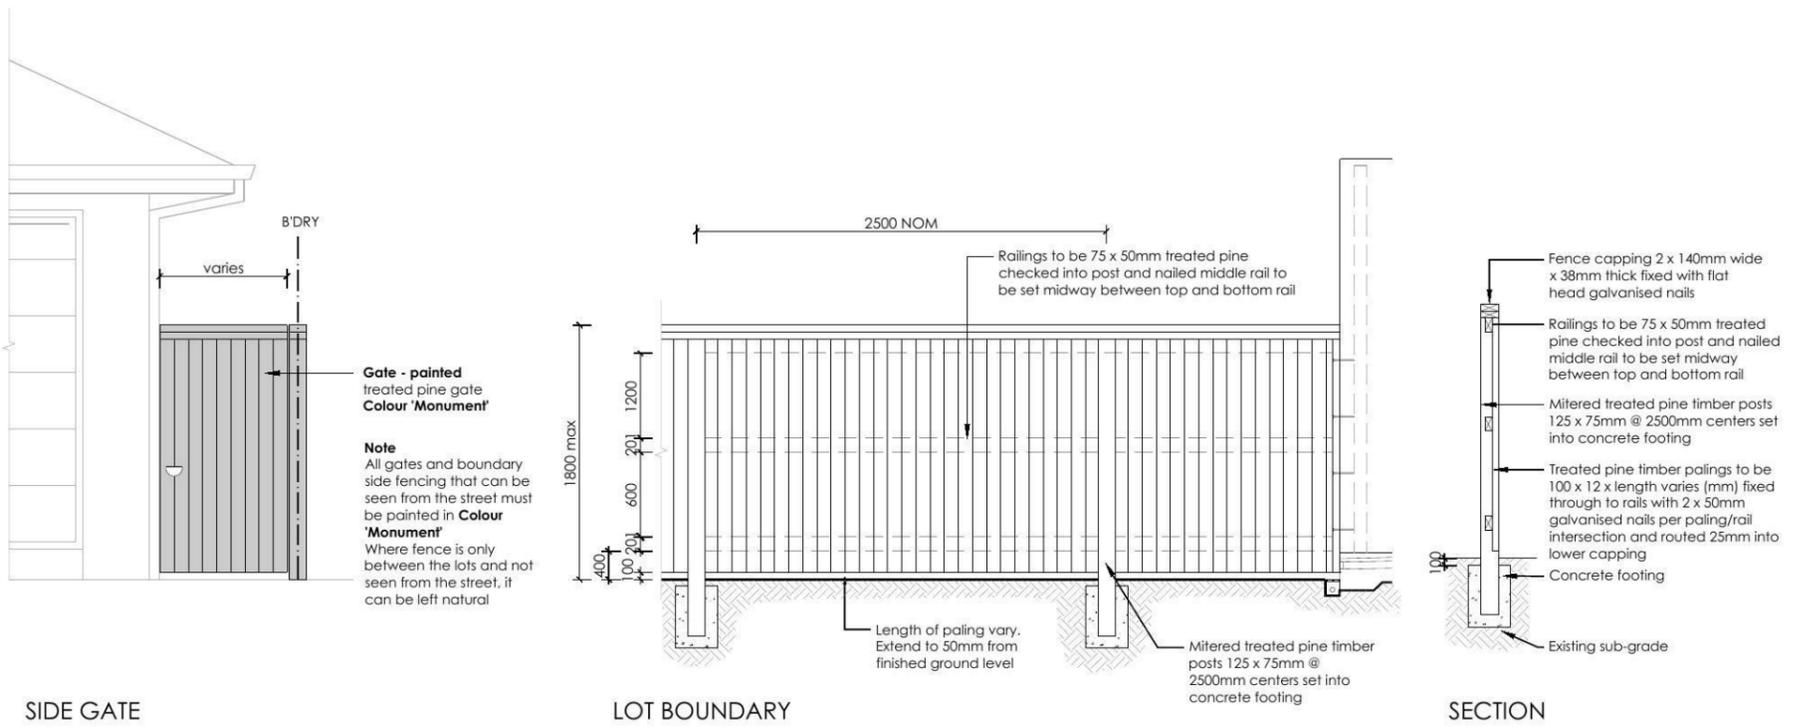


SIDE GATE

LOT BOUNDARY

SECTION


**7 FENCE TYPE 4a - Side Boundaries**  
1:50 Typical detail

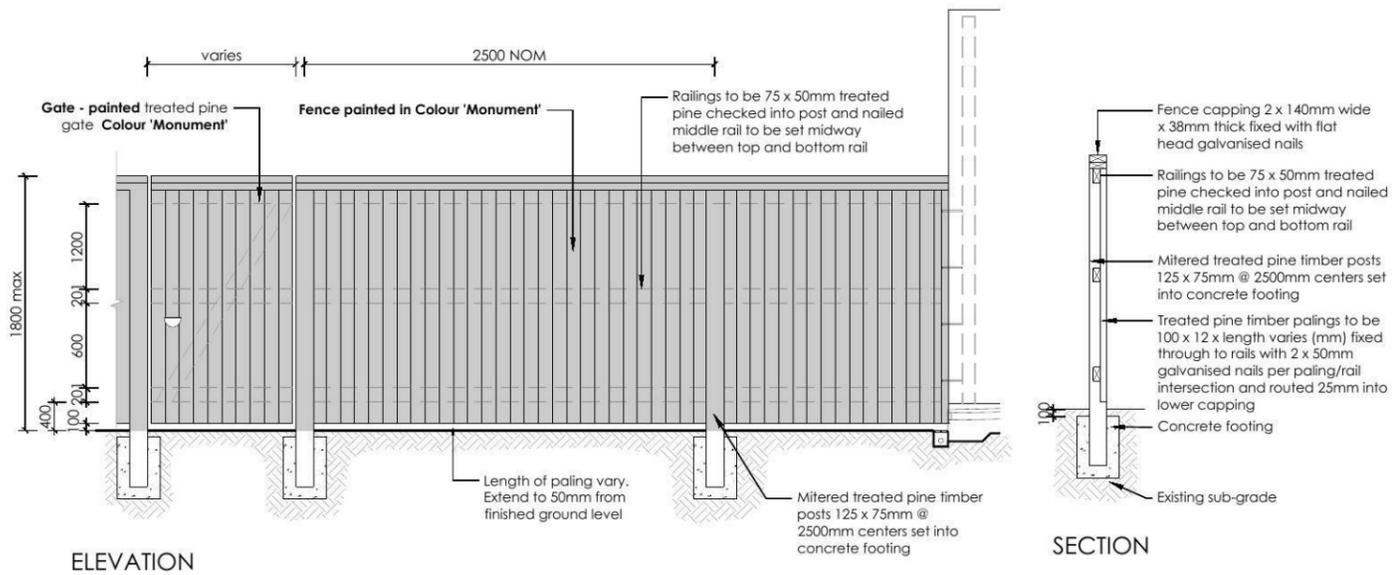

ELEVATION

SECTION

**8 FENCE TYPE 4b - Rear Boundary**  
1:50 All Laneways (except Barlett Lane)  
Typical detail

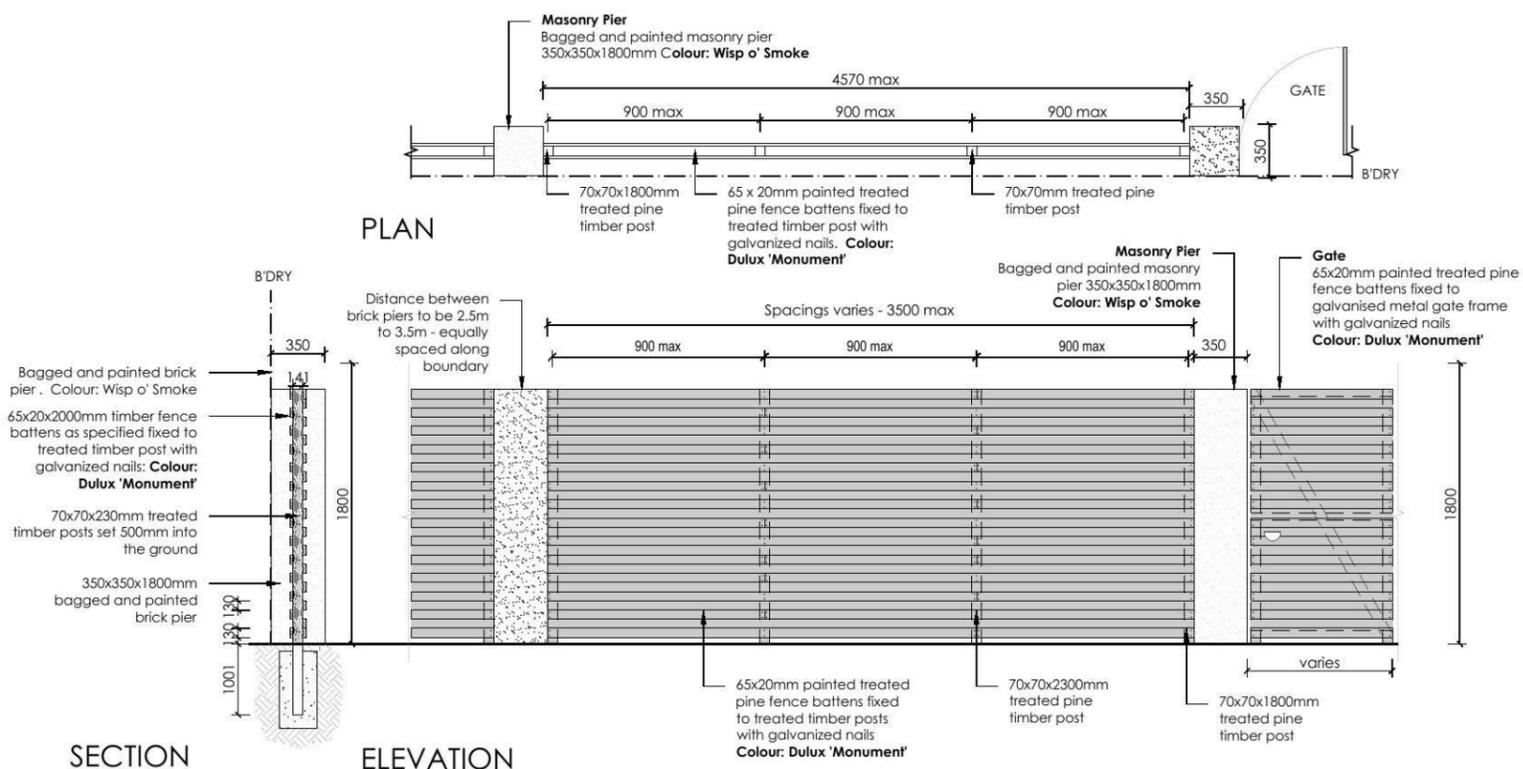

SECTION

ELEVATION

**9 FENCE TYPE 2a - Secondary Street Fencing**  
1:50 Typical detail

REVISION	DESCRIPTION	DRAWN	CHECK	DATE
A	ISSUE FOR CLIENT REVIEW	RS	BT	17-03-14
B	AMEND DIMENSION TO WIR. ISSUE TO URBANGROWTH	RS	RS	18-03-14
C	ADD STREET PLANTING ALONG TYPE 2A FENCING	RS	RS	18-03-14
D	ADD SUB-STATION	RS	RS	20-03-14
E	CHANGE STUDY TO BED 4 REQUESTED BY URBANGROWTH	RS	RS	17-04-14
F	AMEND FRONT FENCE TO TYPE 1B	RS	RS	23-05-14
G	UPDATE ARCHITECTURALS + RE-ISSUE DA PLANS	RS	RS	04-09-14

**ecodesign**  
outdoor living environments

PO Box 8136, Baulkham Hills BC, NSW 2153  
Ph: (02) 9480 7712 Fax: (02) 9480 7705  
Email: info@ecodesign.com.au  
Web: www.ecodesign.com.au  
Member of the Australian Institute of Landscape Designers and Planners

1. Do not scale from drawings.  
2. Verify all measurements on site.  
3. Notify ecodesign of any inconsistencies.  
4. Copyright © ecodesign. All rights reserved.  
5. Drawing remains the property of ecodesign.

6. All work to comply with relevant Australian Standards or Building Code of Australia.  
7. All work to be performed by a suitably qualified tradesperson.  
8. For application purposes only - NOT FOR CONSTRUCTION

ADDRESS: **LOT 2355 WILLIAM HART CRESCENT, PENRITH**

CLIENT: **WISDOM HOMES**

PROJECT: **NEW RESIDENCE**


DRAWING: **LANDSCAPE PLAN**

SCALE: **1:100 @ A3** | DATE: **DA** | SHEET: **04**


DRAWN: **RS** | CHECK: **RS** | DATE: **04-09-14** | REVISION: **G**



# Abode 27 Classic

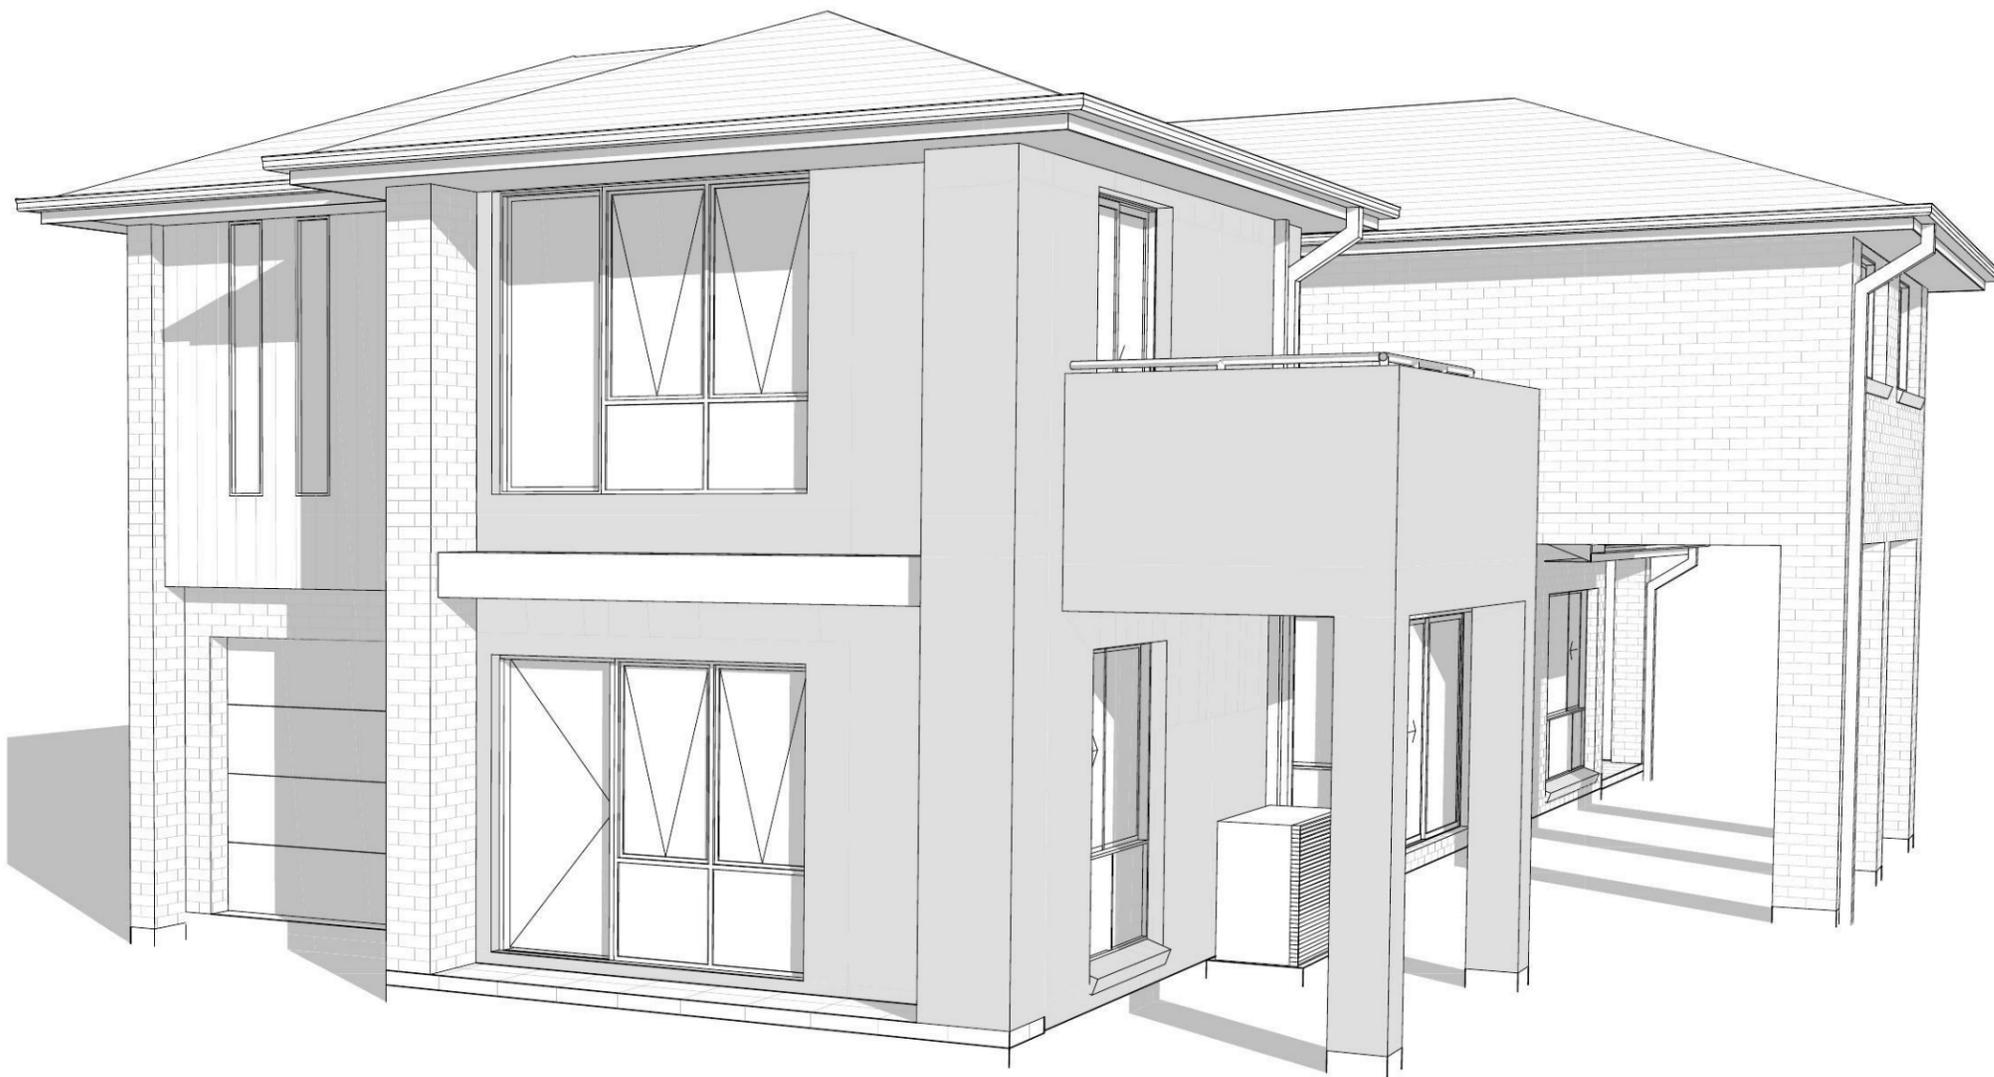

Page	Drawing
2	SITE PLAN
3	BENCHING PLAN
4	STORMWATER PLAN
5	SITE ANALYSIS PLAN
6	GROUND FLOOR PLAN
7	FIRST FLOOR PLAN
8	ELEVATIONS
9	ELEVATIONS
10	SECTIONS
11	WINDOW/DOOR SCHEDULE
12	ELECTRICAL PLAN
13	GROUND FLOOR WET AREA DETAILS
14	FIRST FLOOR WET AREA DETAILS
15	FIRST FLOOR WET AREA DETAILS
16	SHADOW DIAGRAMS

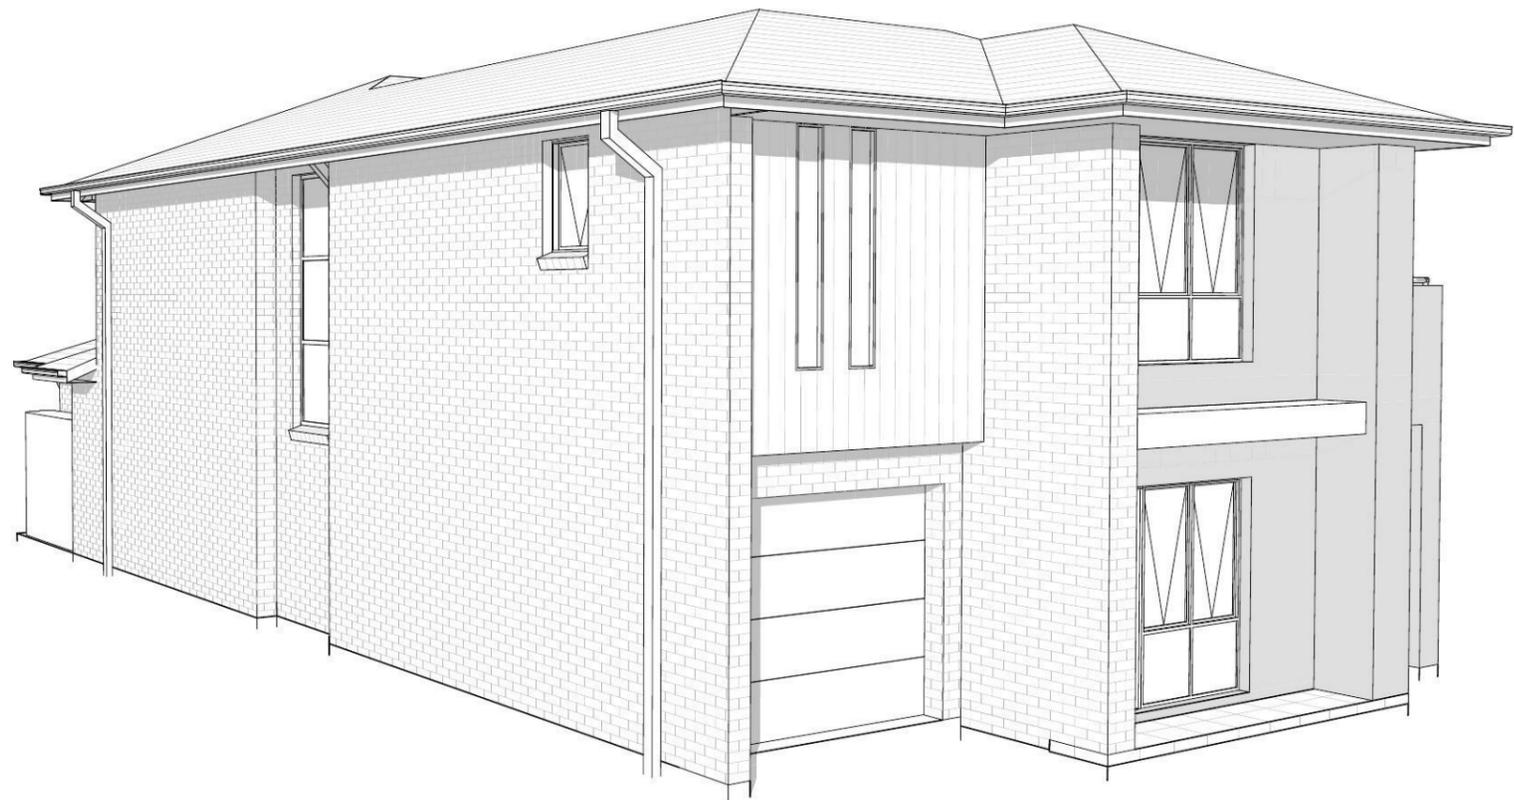

**Wisdom  
Smart  
Theeasystart**  
Ph: 4647 1200  
Fax: 4647 1233  
[www.wisdomsmart.com.au](http://www.wisdomsmart.com.au)

PROJECT: PROPOSED TWO-STOREY BRICK VENEER DWELLING  
CLIENT: Wisdom Homes Pty Ltd  
ADDRESS: Lot 2355 William Hart Crescent  
Thornton Estate, Penrith

JOB No: 003530

## AREAS SCHEDULE

### SITE DETAILS

LOT NUMBER: 2355  
 DP NUMBER: LINEN  
 SITE AREA: 423.80m<sup>2</sup>

### DWELLING AREAS

GROUND FLOOR LIVING: 105.88m<sup>2</sup>  
 FIRST FLOOR LIVING: 123.57m<sup>2</sup>  
 GARAGE: 20.15m<sup>2</sup>  
 PORCH: 1.68m<sup>2</sup>  
 OUTDOOR LEISURE: 14.40m<sup>2</sup>  
 BALCONY: 4.92m<sup>2</sup>

**TOTAL FLOOR AREA: 270.60m<sup>2</sup>**

DRIVEWAY AND PATH AREA: 18.08m<sup>2</sup>

**TOTAL ROOF AREA: 204.91m<sup>2</sup>**  
 (ROOF AREA TO R/WATER TANK AS PER  
 BASIX CERTIFICATE)

### SITE COVERAGE:

PROPOSED: 160.19m<sup>2</sup>/37.7%

### FLOOR SPACE RATIO:

PROPOSED: 229.45m<sup>2</sup>/54.1%

### LANDSCAPE RATIO:

PROPOSED: 259.82m<sup>2</sup>/61.3%

### PRIVATE OPEN SPACE:

(Min 2.0m dimension)  
 REQUIRED (min.): 84.76m<sup>2</sup>/20.0%  
 PROPOSED: 185.18m<sup>2</sup>/43.6%

### 'M' CLASS

(subject to borehole report)

**LOT: 2355**  
**AREA: 423.8m<sup>2</sup>**


EXCAVATE SITE APPROX. 000mm  
 TO FORM JOB DATUM R.L 00.000  
 (ASSUMED) DATUM POINT 000mm  
 BELOW FINISHED FLOOR LEVEL.  
 EXTENT OF EXCAVATION AND  
 BATTERS TO BE DETERMINED ON  
 SITE.

- (C) - EASEMENT FOR PADMOUNT SUBSTATION 2.75 WIDE
- (D) - RESTRICTION ON THE USE OF LAND
- (E) - RESTRICTION ON THE USE OF LAND

### PRELIMINARY DEPOSITED PLAN

THIS PLAN HAS BEEN COMPILED FROM ARCHITECTURAL  
 PLANS SUPPLIED BY URBANGROWTH NSW. DIMENSIONS  
 AND AREAS SHOWN ARE INDICATIVE ONLY. THE PLAN IS  
 SUBJECT TO FINAL SURVEY AND COMPLIANCE WITH  
 COUNCIL CONDITIONS OF APPROVAL

SITE PLAN  
 1:200

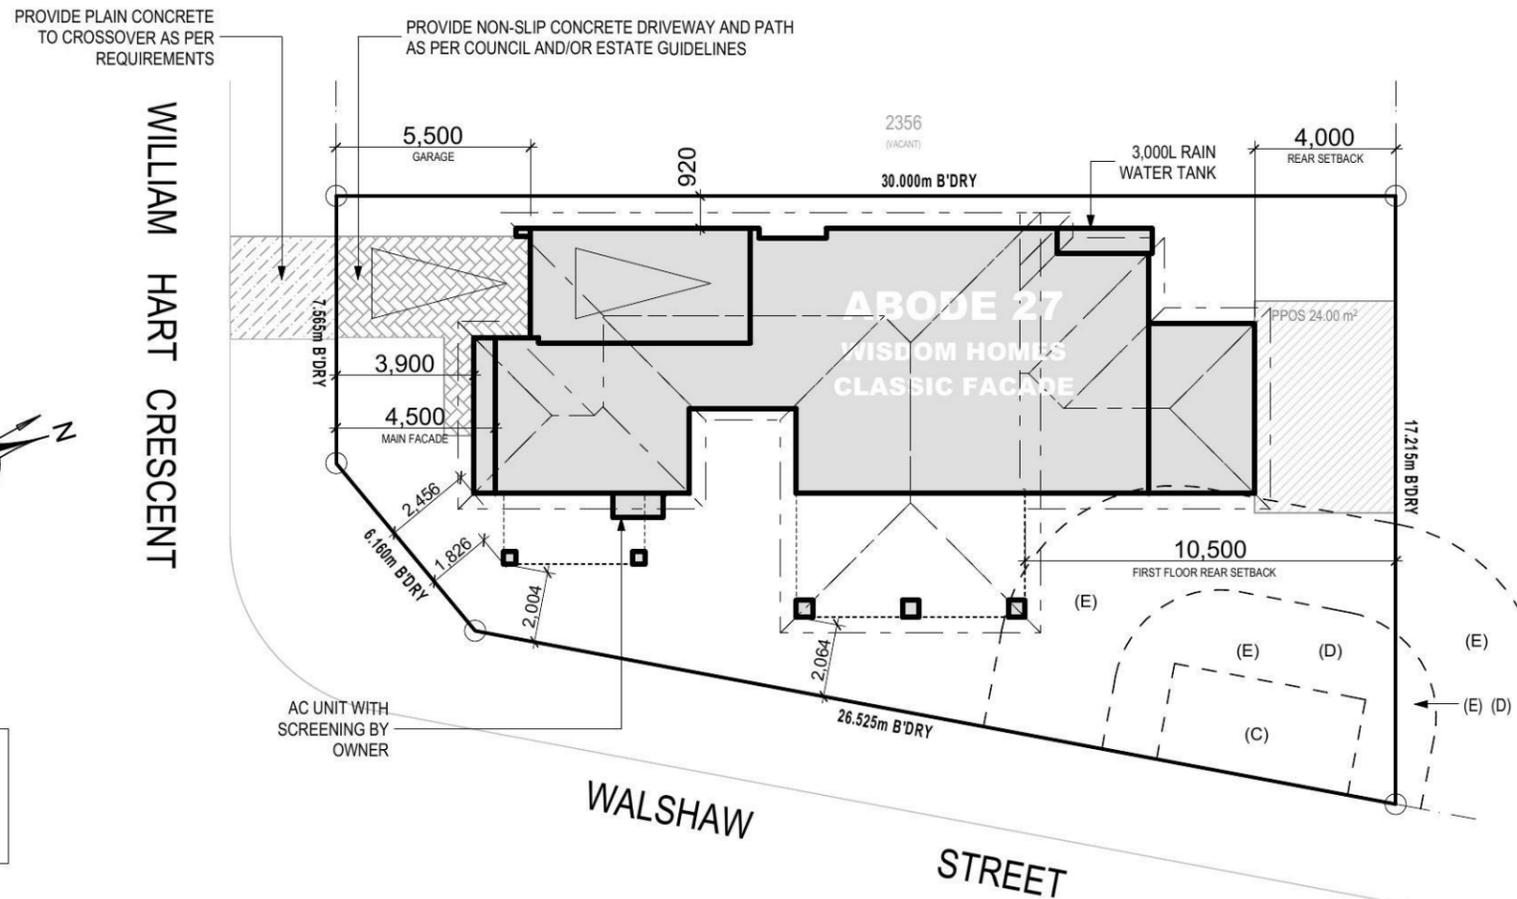

## BASIX NOTES

### WATER

- RAINWATER TANK OF AT LEAST 3,000 LITRES TO BE INSTALLED.
- RAINWATER TANK MUST MEET AND BE INSTALLED IN ACCORDANCE WITH APPLICABLE REGULATORY AUTHORITIES.
- RAINWATER TANK TO COLLECT RAIN RUNOFF FROM AT LEAST 204m<sup>2</sup> OF ROOF AREA.
- RAINWATER TANK SUPPLY TO BE CONNECT TO ALL TOILETS IN THE DEVELOPMENT.
- KITCHEN TAP FITTING RATING: 4 STAR
- SHOWERHEAD RATING: 3 STAR
- TOILET RATING (DUAL FLUSH): 4 STAR
- BATHROOM TAP FITTING RATING: 6 STAR
- RAINWATER TANK TO BE CONNECTED TO AT LEAST ONE OUTDOOR TAP IN THE DEVELOPMENT.

### THERMAL COMFORT

EXTERNAL WALLS: BRICK VEENER/TIMBER FRAME  
 EXTERNAL WALL INSULATION: R2.0  
 EXTERNAL WALL COLOUR: MEDIUM  
 ROOFING MATERIAL: CONCRETE ROOF TILES  
 ROOF INSULATION: SARKING  
 ROOF COLOUR: MEDIUM  
 CEILING INSULATION: R3.5

### ENERGY

- ACTIVE HEATING AND COOLING TO BE INSTALLED IN LIVING AND BEDROOMS, 3 PHASE A/C SYSTEM (EER 2.5-3.0). TO BE DAY/NIGHT ZONED BETWEEN LIVING AREAS AND BEDROOMS. TO BE INSTALLED PRIOR TO FINAL OCCUPATION CERTIFICATE.
- PROVIDE GAS 6 STAR INSTANTANEOUS HWS.
- PROVIDE GAS COOKTOP TO KITCHEN.
- PROVIDE ELECTRIC OVEN TO KITCHEN.
- ALL REFRIGERATOR SPACES TO BE WELL VENTILATED.
- PROVIDE COMPACT FLUORESCENT ENERGY SAVING LIGHT BULBS TO ALL LIGHT POINTS.
- PROVIDE OUTDOOR CLOTHES LINE BY OWNER.

### NOTES:

- \*REFER TO ENGINEERS DETAILS FOR ALL EXPANSION JOINT LOCATIONS.
- \*REFER TO ENGINEERS DETAILS FOR ALL STEEL BEAM AND FLOOR JOIST LOCATIONS AND DIRECTIONS.
- \*REFER TO TRUSS MANUFACTURERS DETAILS FOR ALL FLOOR JOIST SIZES AND DIRECTIONS.
- \*REFER TO A/C DETAILS FOR A/C DUCT POSITIONS.
- \*A/C DUCT LOCATIONS MAY NEED TO CHANGE DUE TO CONSTRUCTION REQUIREMENTS (JOIST LOCATION, STRUCTURAL BEAMS ETC).
- \*FLOOR FINISHES AS SELECTED AS PER TENDER.

# Wisdom Smart

Ph: 4647 1200 Fax: 4647 1233

PROJECT:  
 PROPOSED TWO-STOREY BRICK VENEER DWELLING

ADDRESS:  
 Lot 2355 William Hart Crescent  
 Thornton Estate, Penrith

CLIENT:  
 Wisdom Homes Pty Ltd

LODGEMENT:  
 D.A/C.C

- EXHAUST FAN
- SMOKE DETECTOR. AS 3786-1993

NOTES: BOUNDARY SETBACKS MUST BE VERIFIED BY A REGISTERED SURVEYOR BEFORE COMMENCEMENT OF ANY BUILDING WORK. ALL WORK TO BE CARRIED OUT IN ACCORDANCE WITH THESE DRAWINGS, COUNCIL REQUIREMENTS, RELEVANT CODES & STANDARDS. LEVELS SHOWN ARE BASED ON CONTOUR SURVEY PREPARED BY A REGISTERED SURVEYOR. DRAWINGS ARE TO BE READ IN CONJUNCTION WITH SPECIFICATIONS PROVIDED & ENGINEERS DETAILS. WHERE ENGINEERS STRUCTURAL DRAWINGS ARE REQUIRED THE ENGINEERS PLAN WILL TAKE PREFERENCE TO THESE DRAWINGS. IN THE EVENT OF ANY ALTERATIONS OR DISCREPANCIES, NOTIFY WISDOM HOMES IMMEDIATELY. FIGURED DIMENSIONS TO BE READ IN PREFERENCE TO SCALING & TO BE CHECKED & VERIFIED BEFORE WORK IS COMMENCED.

### REVISION SCHEDULE

ISSUE	DESCRIPTION	DRAWN	DATE
A	CONTRACT PLAN	DC	25/02/14
A-1	CONTRACT AMENDMENTS	DC	10/03/14
A-2	CONTRACT AMENDMENTS	DC	27/03/14
B	DA PLANS	JH	13.05.14
B-1	PLAN AMENDMENTS	AS	14.08.14
-	-	-	-

JOB No:  
**003530**

LGA:  
 PENRITH

DESCRIPTION:  
**ABODE 27**

CODE:  
 WH-ABOD27D CL LH


DRAWN:  
 DC

DATE:  
 25/02/14

SITE CLASSIFICATION:  
 'M' CLASS (subject to borehole report)

FACADE:  
 Classic

SHEET:  
2

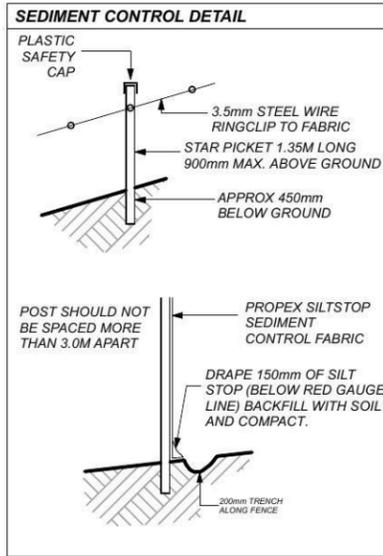

ANY RETAINING WALLS REQUIRED TO BE COMPLETED BY OWNERS TO MANUFACTURERS SPECIFICATIONS.

PROVIDE 1.80m HIGH SECURITY FENCE TO PERIMETER OF SITE AS PER COUNCIL REQUIREMENTS.

PROVIDE TEMPORARY STABILISED VEHICLE ACCESS DRIVEWAY (GRAVEL/ROCK AGGREGATE)

PROVIDE SEDIMENT CONTROL FENCE AS PER COUNCIL REQUIREMENTS.

**'M' CLASS**  
(subject to borehole report)



**LOT: 2355**  
**AREA: 423.8m<sup>2</sup>**

EXCAVATE SITE APPROX. 000mm TO FORM JOB DATUM R.L. 00.000 (ASSUMED) DATUM POINT 000mm BELOW FINISHED FLOOR LEVEL. EXTENT OF EXCAVATION AND BATTERS TO BE DETERMINED ON SITE.

- (C) - EASEMENT FOR PADMOUNT SUBSTATION 2.75 WIDE
- (D) - RESTRICTION ON THE USE OF LAND
- (E) - RESTRICTION ON THE USE OF LAND

**PRELIMINARY DEPOSITED PLAN**

 THIS PLAN HAS BEEN COMPILED FROM ARCHITECTURAL PLANS SUPPLIED BY URBANGROWTH NSW. DIMENSIONS AND AREAS SHOWN ARE INDICATIVE ONLY. THE PLAN IS SUBJECT TO FINAL SURVEY AND COMPLIANCE WITH COUNCIL CONDITIONS OF APPROVAL

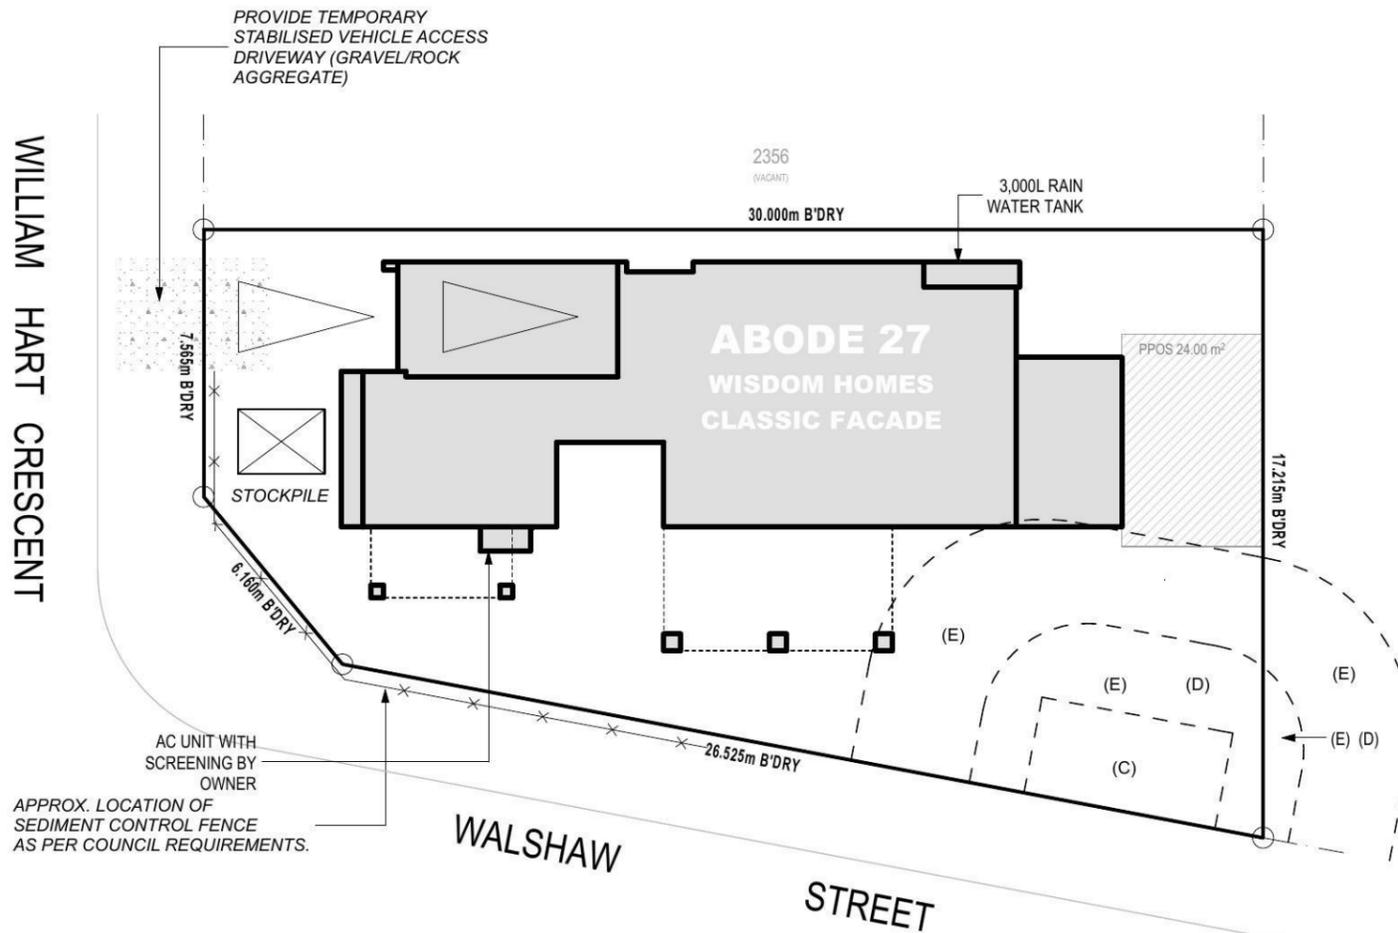

**NOTES:**  
 \*REFER TO ENGINEERS DETAILS FOR ALL EXPANSION JOINT LOCATIONS.  
 \*REFER TO ENGINEERS DETAILS FOR ALL STEEL BEAM AND FLOOR JOIST LOCATIONS AND DIRECTIONS.  
 \*REFER TO TRUSS MANUFACTURERS DETAILS FOR ALL FLOOR JOIST SIZES AND DIRECTIONS.  
 \*REFER TO A/C DETAILS FOR A/C DUCT POSITIONS.  
 \*A/C DUCT LOCATIONS MAY NEED TO CHANGE DUE TO CONSTRUCTION REQUIREMENTS (JOIST LOCATION, STRUCTURAL BEAMS ETC).  
 \*FLOOR FINISHES AS SELECTED AS PER TENDER.

**Wisdom Smart**

Ph: 4647 1200 Fax: 4647 1233

PROJECT:  
PROPOSED TWO-STOREY BRICK VENEER DWELLING

ADDRESS:  
**Lot 2355 William Hart Crescent**  
**Thornton Estate, Penrith**

CLIENT:  
**Wisdom Homes Pty Ltd**

LODGEMENT:  
**D.A/C.C**

- ⊗ EXHAUST FAN
- ⊗ SMOKE DETECTOR. AS 3786-1993

NOTES: BOUNDARY SETBACKS MUST BE VERIFIED BY A REGISTERED SURVEYOR BEFORE COMMENCEMENT OF ANY BUILDING WORK. ALL WORK TO BE CARRIED OUT IN ACCORDANCE WITH THESE DRAWINGS, COUNCIL REQUIREMENTS, RELEVANT CODES & STANDARDS. LEVELS SHOWN ARE BASED ON CONTOUR SURVEY PREPARED BY A REGISTERED SURVEYOR. DRAWINGS ARE TO BE READ IN CONJUNCTION WITH SPECIFICATIONS PROVIDED & ENGINEERS DETAILS. WHERE ENGINEERS STRUCTURAL DRAWINGS ARE REQUIRED THE ENGINEERS PLAN WILL TAKE PREFERENCE TO THESE DRAWINGS. IN THE EVENT OF ANY ALTERATIONS OR DISCREPANCIES, NOTIFY WISDOM HOMES IMMEDIATELY. FIGURED DIMENSIONS TO BE READ IN PREFERENCE TO SCALING & TO BE CHECKED & VERIFIED BEFORE WORK IS COMMENCED.

REVISION SCHEDULE			
ISSUE	DESCRIPTION	DRAWN	DATE
A	CONTRACT PLAN	DC	25/02/14
A-1	CONTRACT AMENDMENTS	DC	10/03/14
A-2	CONTRACT AMENDMENTS	DC	27/03/14
B	DA PLANS	JH	13.05.14
B-1	PLAN AMENDMENTS	AS	14.08.14
-	-	-	-

JOB No:  
**003530**

DATE:  
**25/02/14**

LGA:  
**PENRITH**

DESCRIPTION:  
**ABODE 27**

CODE:  
**WH-ABOD27D CL LH**

DRAWN:  
**DC**

DATE:  
**25/02/14**

SITE CLASSIFICATION:  
**'M' CLASS** (subject to borehole report)

FACADE:  
**Classic**

SHEET:  
**3**

The stormwater design/layout which flows to the street/easement is in compliance with:

1. Building Code of Australia Vol. 2 (BCA) Sections 3.1 Site Preparation, and 3.5 Roof and Wall Cladding.
2. Penrith City Council DCP 2006 Guidelines for Engineering works (stormwater drainage).
3. Using data from BCA Tables 3.5.2.1 and 3.5.2.2 the number of downpipes required based on a roof area of 204m<sup>2</sup> is 7.

Name \_\_\_\_\_

Signed \_\_\_\_\_ Date \_\_\_\_\_

**'M' CLASS**

(subject to borehole report)

**LOT: 2355**  
**AREA: 423.8m<sup>2</sup>**

EXCAVATE SITE APPROX. 000mm TO FORM JOB DATUM R.L. 00.000 (ASSUMED) DATUM POINT 000mm BELOW FINISHED FLOOR LEVEL. EXTENT OF EXCAVATION AND BATTERS TO BE DETERMINED ON SITE.


- (C) - EASEMENT FOR PADMOUNT SUBSTATION 2.75 WIDE
- (D) - RESTRICTION ON THE USE OF LAND
- (E) - RESTRICTION ON THE USE OF LAND

**PRELIMINARY DEPOSITED PLAN**

THIS PLAN HAS BEEN COMPILED FROM ARCHITECTURAL PLANS SUPPLIED BY URBANGROWTH NSW. DIMENSIONS AND AREAS SHOWN ARE INDICATIVE ONLY. THE PLAN IS SUBJECT TO FINAL SURVEY AND COMPLIANCE WITH COUNCIL CONDITIONS OF APPROVAL



WILLIAM HART CRESCENT

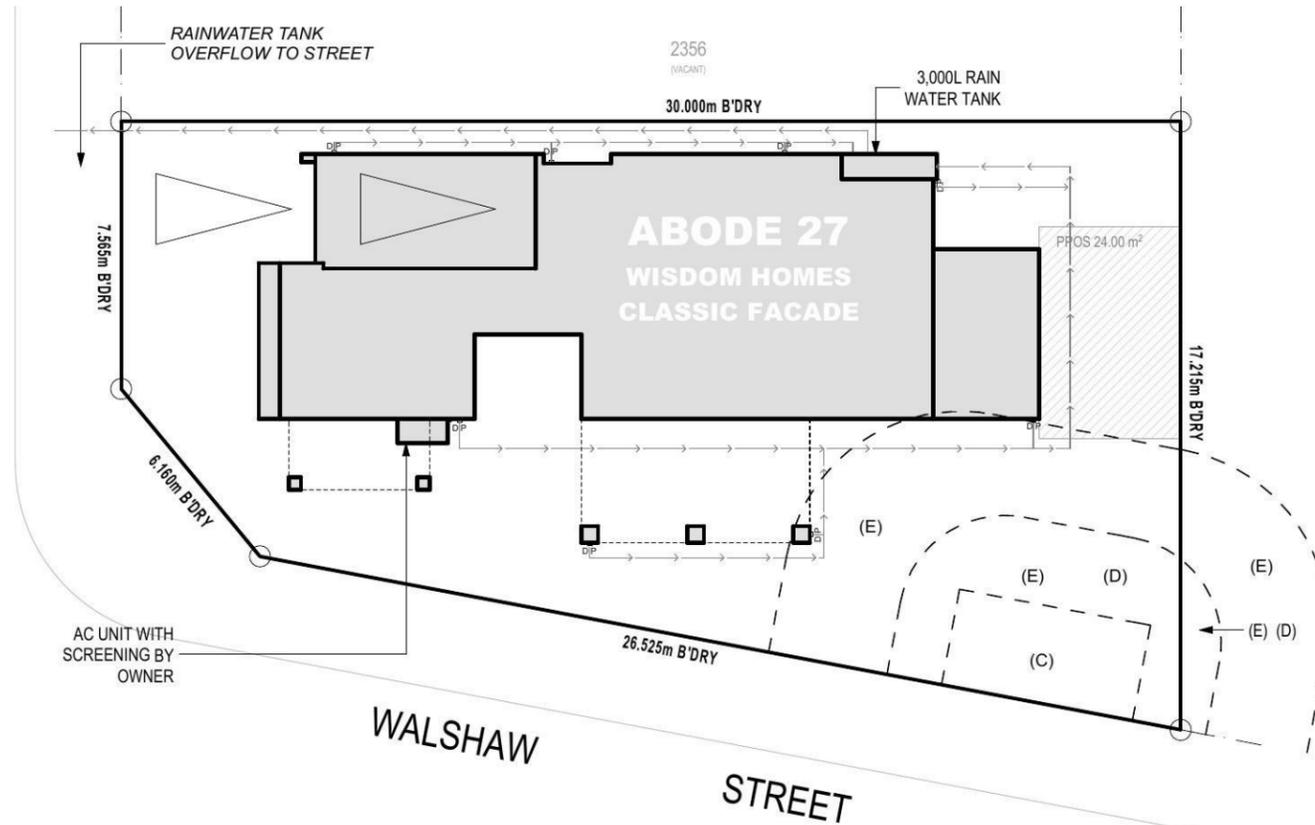

STORMWATER PLAN  
1:200

**NOTES:**  
 \*REFER TO ENGINEERS DETAILS FOR ALL EXPANSION JOINT LOCATIONS.  
 \*REFER TO ENGINEERS DETAILS FOR ALL STEEL BEAM AND FLOOR JOIST LOCATIONS AND DIRECTIONS.  
 \*REFER TO TRUSS MANUFACTURERS DETAILS FOR ALL FLOOR JOIST SIZES AND DIRECTIONS.  
 \*REFER TO A/C DETAILS FOR A/C DUCT POSITIONS.  
 \*A/C DUCT LOCATIONS MAY NEED TO CHANGE DUE TO CONSTRUCTION REQUIREMENTS (JOIST LOCATION, STRUCTURAL BEAMS ETC).  
 \*FLOOR FINISHES AS SELECTED AS PER TENDER.



Ph: 4647 1200 Fax: 4647 1233

PROJECT:  
PROPOSED TWO-STOREY BRICK VENEER DWELLING

ADDRESS:  
Lot 2355 William Hart Crescent  
Thornton Estate, Penrith

CLIENT:  
Wisdom Homes Pty Ltd

LODGEMENT:  
D.A/C.C

- ⊗ EXHAUST FAN
- ⊗ SMOKE DETECTOR. AS 3786-1993

NOTES: BOUNDARY SETBACKS MUST BE VERIFIED BY A REGISTERED SURVEYOR BEFORE COMMENCEMENT OF ANY BUILDING WORK. ALL WORK TO BE CARRIED OUT IN ACCORDANCE WITH THESE DRAWINGS, COUNCIL REQUIREMENTS, RELEVANT CODES & STANDARDS. LEVELS SHOWN ARE BASED ON CONTOUR SURVEY PREPARED BY A REGISTERED SURVEYOR. DRAWINGS ARE TO BE READ IN CONJUNCTION WITH SPECIFICATIONS PROVIDED & ENGINEERS DETAILS. WHERE ENGINEERS STRUCTURAL DRAWINGS ARE REQUIRED THE ENGINEERS PLAN WILL TAKE PREFERENCE TO THESE DRAWINGS. IN THE EVENT OF ANY ALTERATIONS OR DISCREPANCIES, NOTIFY WISDOM HOMES IMMEDIATELY. FIGURED DIMENSIONS TO BE READ IN PREFERENCE TO SCALING & TO BE CHECKED & VERIFIED BEFORE WORK IS COMMENCED.

REVISION SCHEDULE			
ISSUE	DESCRIPTION	DRAWN	DATE
A	CONTRACT PLAN	DC	25/02/14
A-1	CONTRACT AMENDMENTS	DC	10/03/14
A-2	CONTRACT AMENDMENTS	DC	27/03/14
B	DA PLANS	JH	13.05.14
B-1	PLAN AMENDMENTS	AS	14.08.14
-	-	-	-

JOB No:  
**003530**

DATE:  
**25/02/14**

LGA:  
**PENRITH**

DESCRIPTION:  
**ABODE 27**

CODE:  
**WH-ABOD27D CL LH**

DRAWN:  
DC

DATE:  
25/02/14

SITE CLASSIFICATION:  
**'M' CLASS** (subject to borehole report)

FACADE:  
**Classic**

SHEET:  
**4**

**'M' CLASS**  
(subject to borehole report)

**LOT: 2355**  
**AREA: 423.8m<sup>2</sup>**

EXCAVATE SITE APPROX. 000mm TO FORM JOB DATUM R.L 00.000 (ASSUMED) DATUM POINT 000mm BELOW FINISHED FLOOR LEVEL. EXTENT OF EXCAVATION AND BATTERS TO BE DETERMINED ON SITE.


- (C) - EASEMENT FOR PADMOUNT SUBSTATION 2.75 WIDE
- (D) - RESTRICTION ON THE USE OF LAND
- (E) - RESTRICTION ON THE USE OF LAND

**PRELIMINARY DEPOSITED PLAN**

THIS PLAN HAS BEEN COMPILED FROM ARCHITECTURAL PLANS SUPPLIED BY URBANGROWTH NSW. DIMENSIONS AND AREAS SHOWN ARE INDICATIVE ONLY. THE PLAN IS SUBJECT TO FINAL SURVEY AND COMPLIANCE WITH COUNCIL CONDITIONS OF APPROVAL



WILLIAM HART CRESCENT

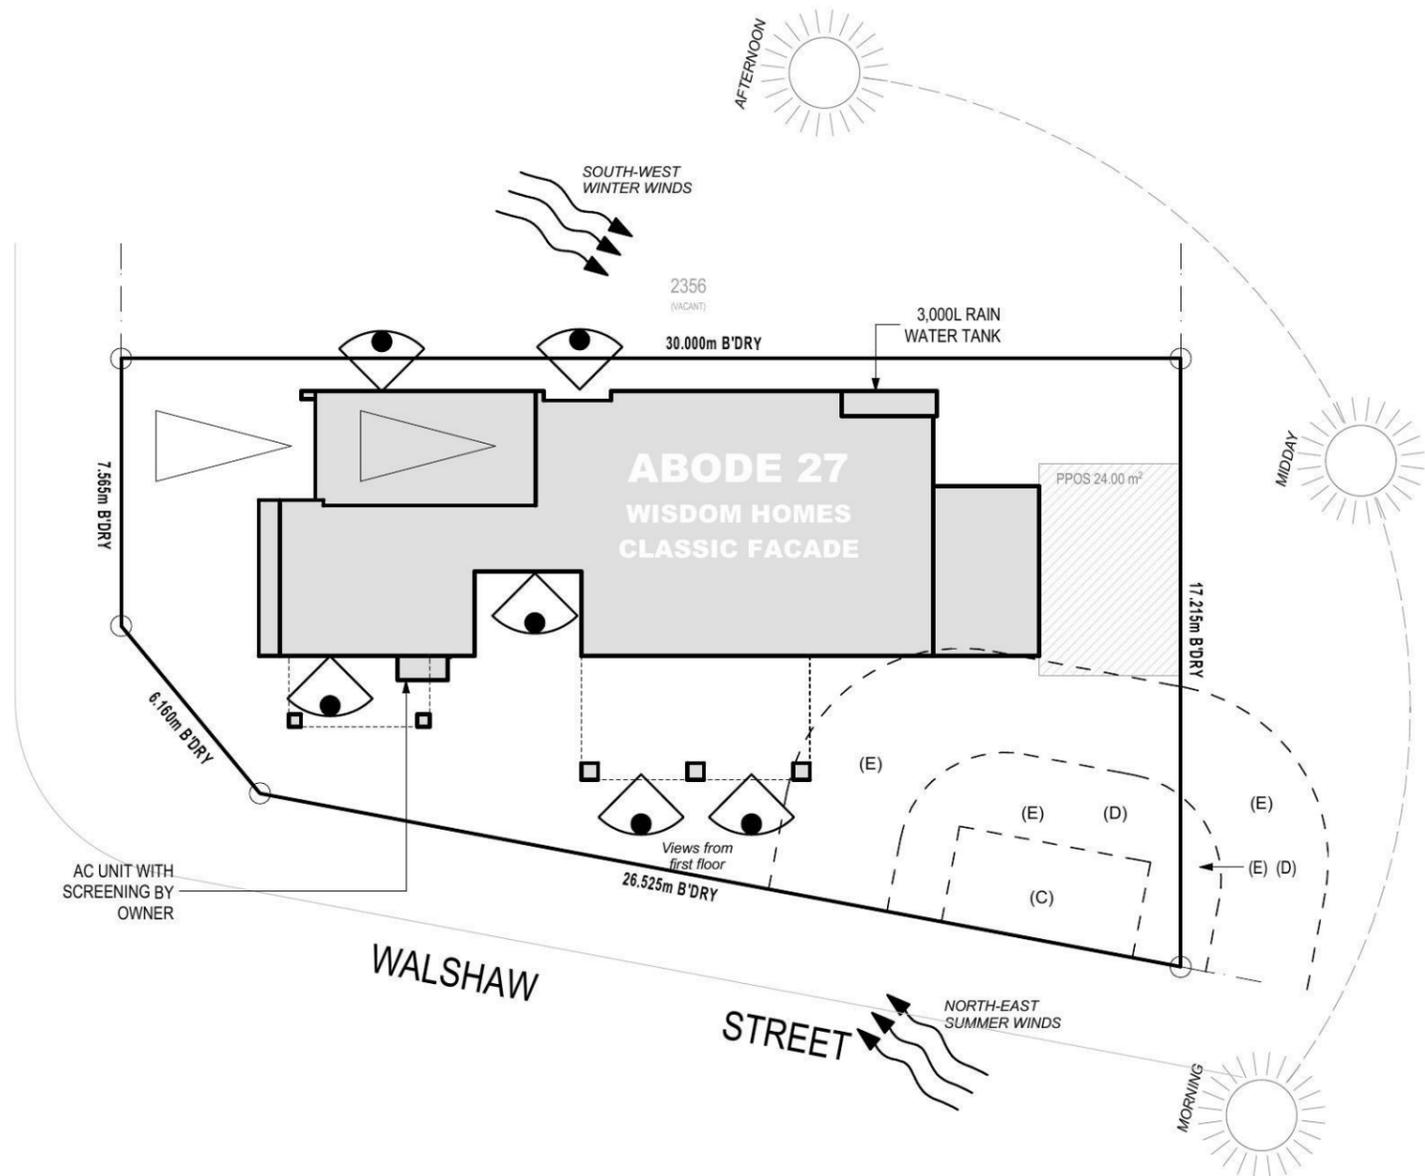

**SITE ANALYSIS PLAN**  
1:200

**NOTES:**  
 \*REFER TO ENGINEERS DETAILS FOR ALL EXPANSION JOINT LOCATIONS.  
 \*REFER TO ENGINEERS DETAILS FOR ALL STEEL BEAM AND FLOOR JOIST LOCATIONS AND DIRECTIONS.  
 \*REFER TO TRUSS MANUFACTURERS DETAILS FOR ALL FLOOR JOIST SIZES AND DIRECTIONS.  
 \*REFER TO A/C DETAILS FOR A/C DUCT POSITIONS.  
 \*A/C DUCT LOCATIONS MAY NEED TO CHANGE DUE TO CONSTRUCTION REQUIREMENTS (JOIST LOCATION, STRUCTURAL BEAMS ETC).  
 \*FLOOR FINISHES AS SELECTED AS PER TENDER.



PROJECT:  
PROPOSED TWO-STOREY BRICK VENEER DWELLING

ADDRESS:  
**Lot 2355 William Hart Crescent**  
**Thornton Estate, Penrith**

CLIENT:  
**Wisdom Homes Pty Ltd**

LODGEMENT:  
**D.A/C.C**

EXHAUST FAN  
 SMOKE DETECTOR. AS 3786-1993

NOTES: BOUNDARY SETBACKS MUST BE VERIFIED BY A REGISTERED SURVEYOR BEFORE COMMENCEMENT OF ANY BUILDING WORK. ALL WORK TO BE CARRIED OUT IN ACCORDANCE WITH THESE DRAWINGS, COUNCIL REQUIREMENTS, RELEVANT CODES & STANDARDS. LEVELS SHOWN ARE BASED ON CONTOUR SURVEY PREPARED BY A REGISTERED SURVEYOR. DRAWINGS ARE TO BE READ IN CONJUNCTION WITH SPECIFICATIONS PROVIDED & ENGINEERS DETAILS. WHERE ENGINEERS STRUCTURAL DRAWINGS ARE REQUIRED THE ENGINEERS PLAN WILL TAKE PREFERENCE TO THESE DRAWINGS. IN THE EVENT OF ANY ALTERATIONS OR DISCREPANCIES, NOTIFY WISDOM HOMES IMMEDIATELY. FIGURED DIMENSIONS TO BE READ IN PREFERENCE TO SCALING & TO BE CHECKED & VERIFIED BEFORE WORK IS COMMENCED.

REVISION SCHEDULE			
ISSUE	DESCRIPTION	DRAWN	DATE
A	CONTRACT PLAN	DC	25/02/14
A-1	CONTRACT AMENDMENTS	DC	10/03/14
A-2	CONTRACT AMENDMENTS	DC	27/03/14
B	DA PLANS	JH	13.05.14
B-1	PLAN AMENDMENTS	AS	14.08.14
-	-	-	-

JOB No:  
**003530**

DATE:  
**25/02/14**

LGA:  
**PENRITH**

DESCRIPTION:  
**ABODE 27**

CODE:  
**WH-ABOD27D CL LH**


DRAWN:  
**DC**

DATE:  
**25/02/14**


SITE CLASSIFICATION:  
**'M' CLASS** (subject to borehole report)

FACADE:  
**Classic**


SHEET:  
**5**

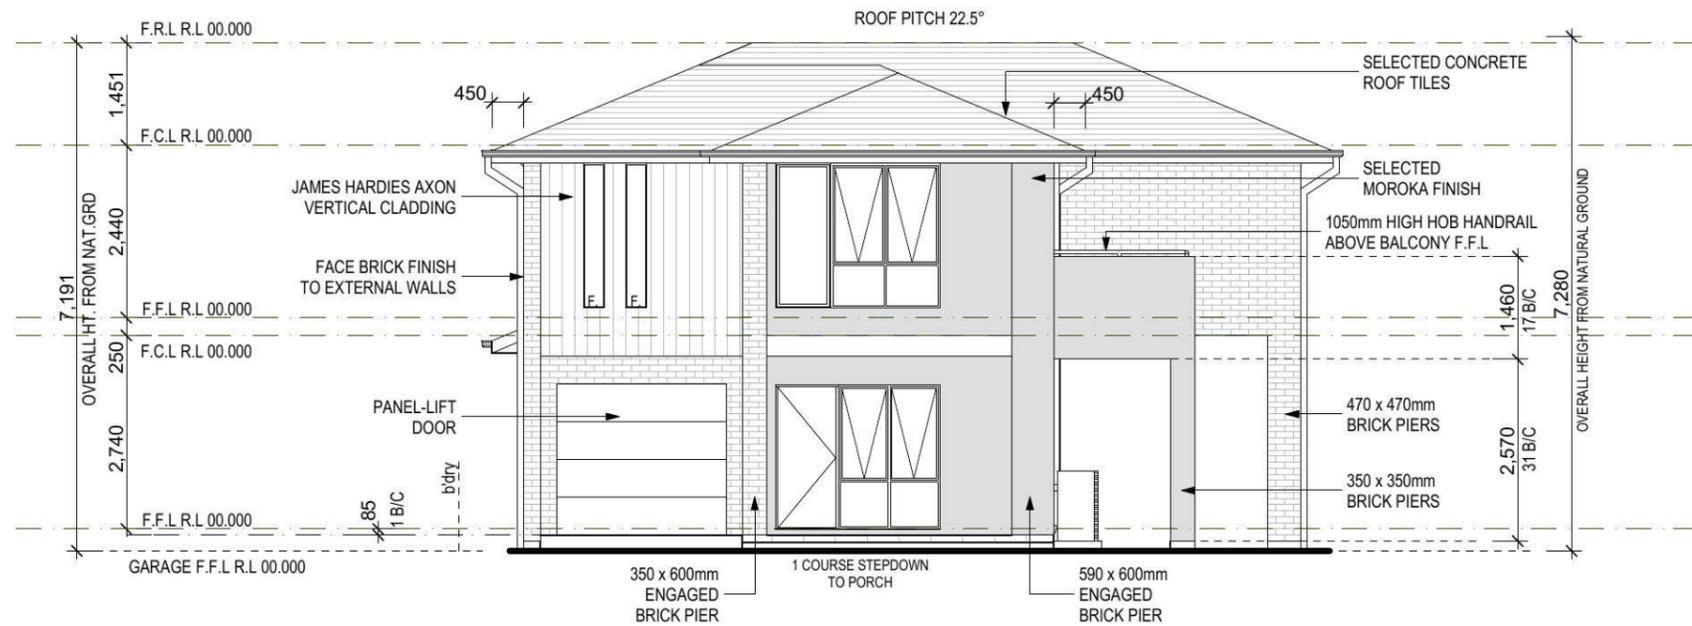

**NOTE:**  
 \*OPENABLE WINDOWS IN ACCORDANCE WITH CLAUSE 3.9.2.5 OF THE BCA 2013 VOL 2.  
 FIRST FLOOR WINDOWS TO BE RESTRICTED TO OPEN A MAX. OF 125mm IF SILL HEIGHT IS LOWER THAN 1700mm ABOVE A FLOOR LEVEL.

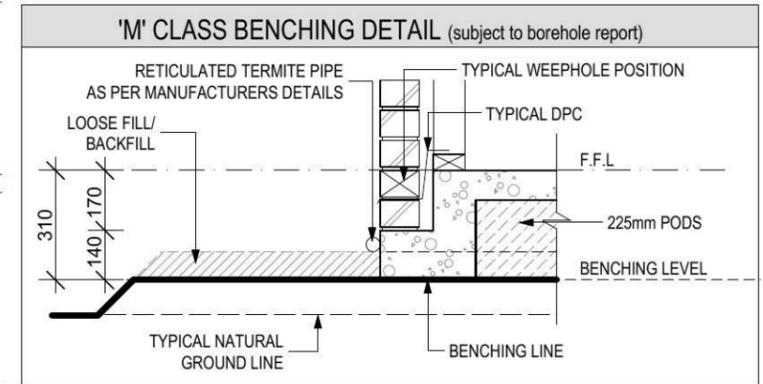

FRONT/SOUTH ELEVATION  
 1:100

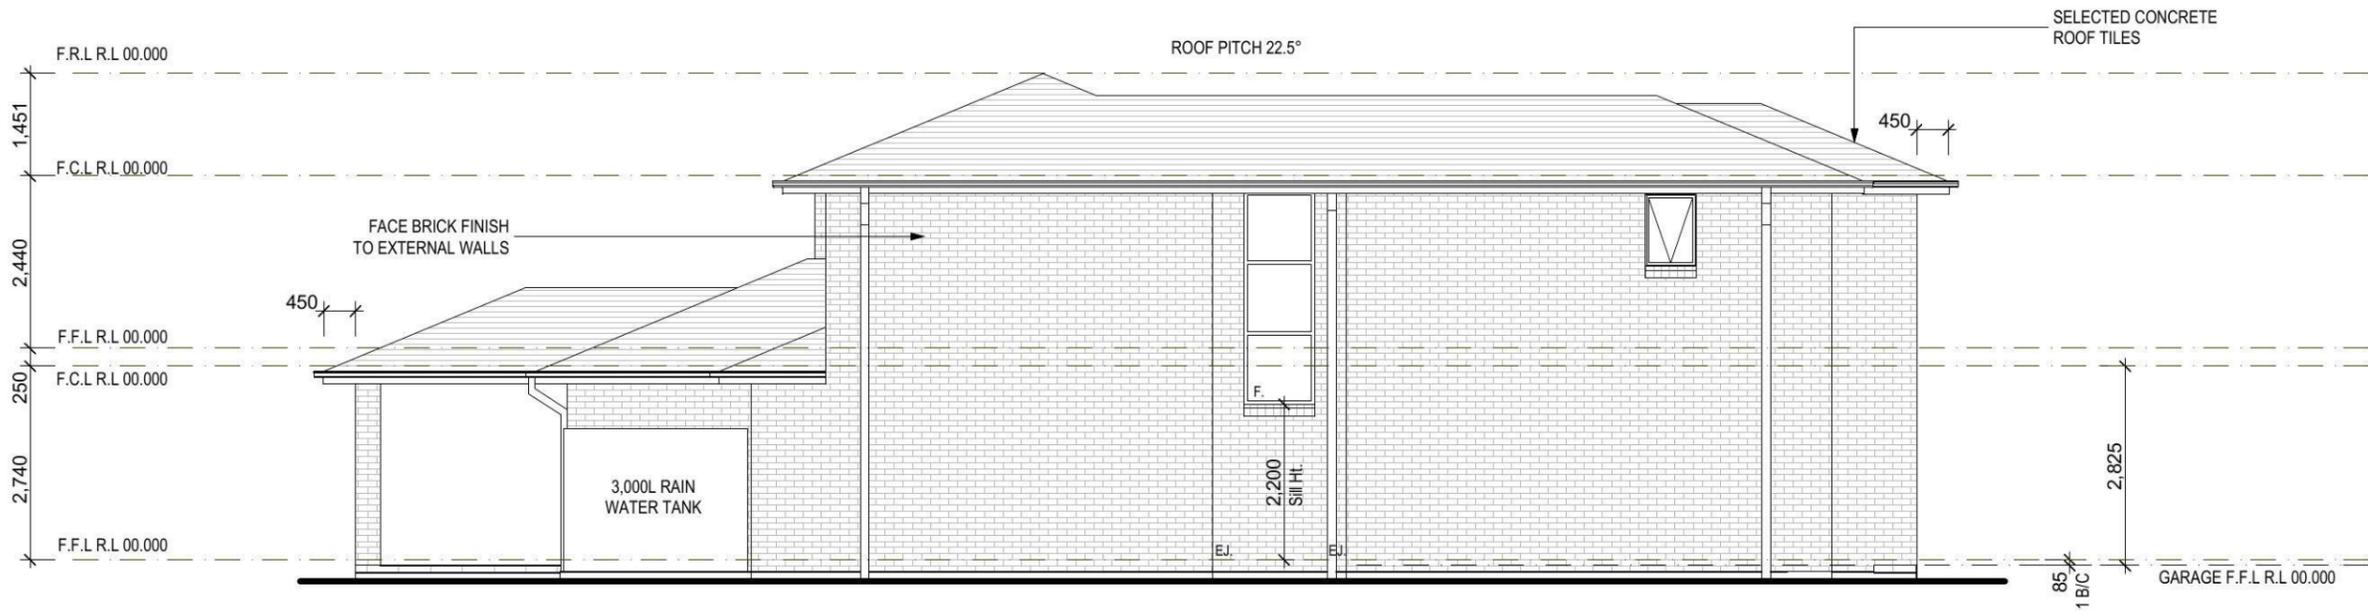

LEFT/WEST ELEVATION  
 1:100

**NOTES:**  
 \*REFER TO ENGINEERS DETAILS FOR ALL EXPANSION JOINT LOCATIONS.  
 \*REFER TO ENGINEERS DETAILS FOR ALL STEEL BEAM AND FLOOR JOIST LOCATIONS AND DIRECTIONS.  
 \*REFER TO TRUSS MANUFACTURERS DETAILS FOR ALL FLOOR JOIST SIZES AND DIRECTIONS.  
 \*REFER TO A/C DETAILS FOR A/C DUCT POSITIONS.  
 \*A/C DUCT LOCATIONS MAY NEED TO CHANGE DUE TO CONSTRUCTION REQUIREMENTS (JOIST LOCATION, STRUCTURAL BEAMS ETC).  
 \*FLOOR FINISHES AS SELECTED AS PER TENDER.



PROJECT:  
 PROPOSED TWO-STOREY BRICK VENEER DWELLING  
 ADDRESS:  
 Lot 2355 William Hart Crescent  
 Thornton Estate, Penrith  
 CLIENT:  
 Wisdom Homes Pty Ltd


LODGEMENT:  
 D.A/C.C  
 EXHAUST FAN  
 SMOKE DETECTOR. AS 3786-1993

NOTES: BOUNDARY SETBACKS MUST BE VERIFIED BY A REGISTERED SURVEYOR BEFORE COMMENCEMENT OF ANY BUILDING WORK. ALL WORK TO BE CARRIED OUT IN ACCORDANCE WITH THESE DRAWINGS, COUNCIL REQUIREMENTS, RELEVANT CODES & STANDARDS. LEVELS SHOWN ARE BASED ON CONTOUR SURVEY PREPARED BY A REGISTERED SURVEYOR. DRAWINGS ARE TO BE READ IN CONJUNCTION WITH SPECIFICATIONS PROVIDED & ENGINEERS DETAILS. WHERE ENGINEERS STRUCTURAL DRAWINGS ARE REQUIRED THE ENGINEERS PLAN WILL TAKE PREFERENCE TO THESE DRAWINGS. IN THE EVENT OF ANY ALTERATIONS OR DISCREPANCIES, NOTIFY WISDOM HOMES IMMEDIATELY. FIGURED DIMENSIONS TO BE READ IN PREFERENCE TO SCALING & TO BE CHECKED & VERIFIED BEFORE WORK IS COMMENCED.


REVISION SCHEDULE			
ISSUE	DESCRIPTION	DRAWN	DATE
A	CONTRACT PLAN	DC	25/02/14
A-1	CONTRACT AMENDMENTS	DC	10/03/14
A-2	CONTRACT AMENDMENTS	DC	27/03/14
B	DA PLANS	JH	13.05.14
B-1	PLAN AMENDMENTS	AS	14.08.14
-	-	-	-

JOB No:  
 003530  
 LGA:  
 PENRITH  
 DESCRIPTION:  
 ABODE 27  
 CODE:  
 WH-ABOD27D CL LH

DRAWN:  
 DC  
 DATE:  
 25/02/14  
 SITE CLASSIFICATION:  
 'M' CLASS (subject to borehole report)  
 FACADE:  
 Classic  
 SHEET:  
 8

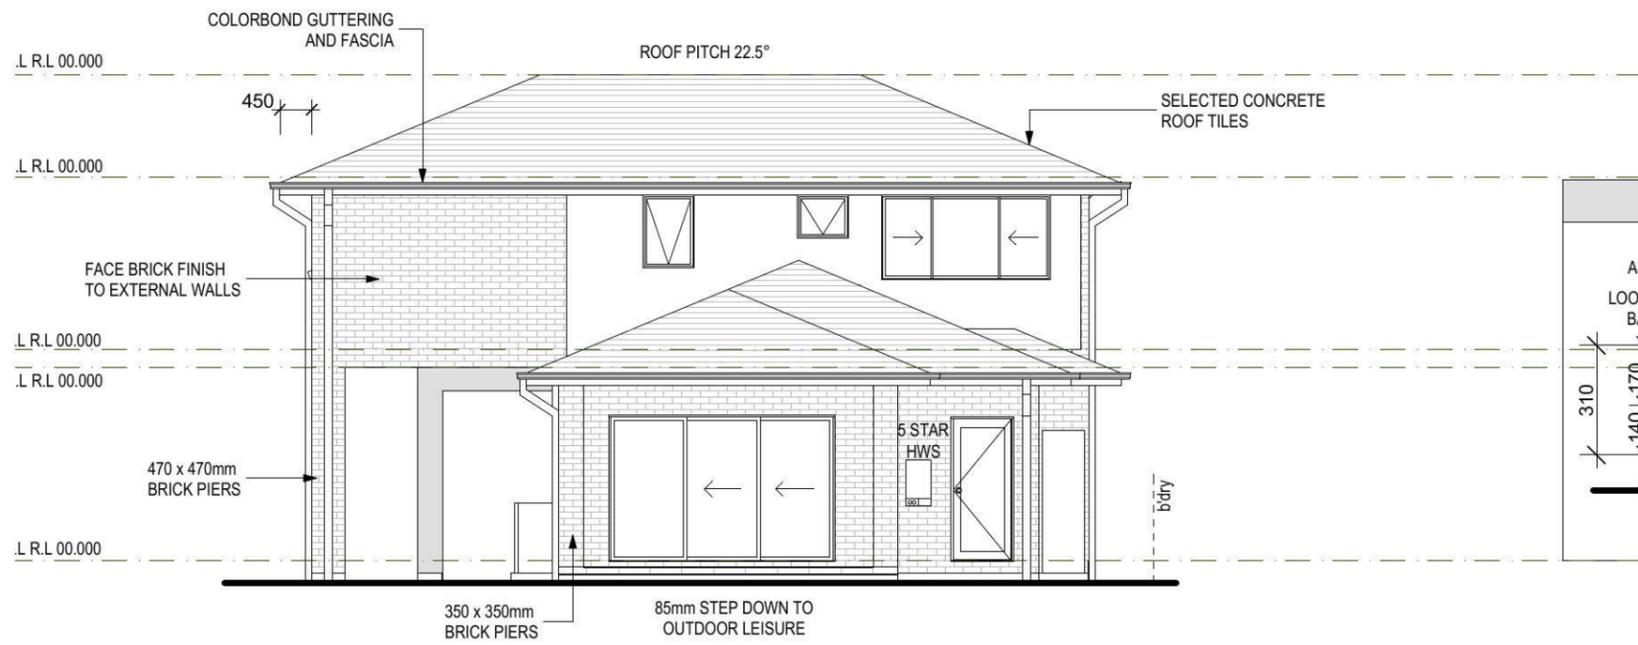

**NOTE:**  
 \*OPENABLE WINDOWS IN ACCORDANCE WITH CLAUSE 3.9.2.5 OF THE BCA 2013 VOL 2.  
 FIRST FLOOR WINDOWS TO BE RESTRICTED TO OPEN A MAX. OF 125mm IF SILL HEIGHT IS LOWER THAN 1700mm ABOVE A FLOOR LEVEL.

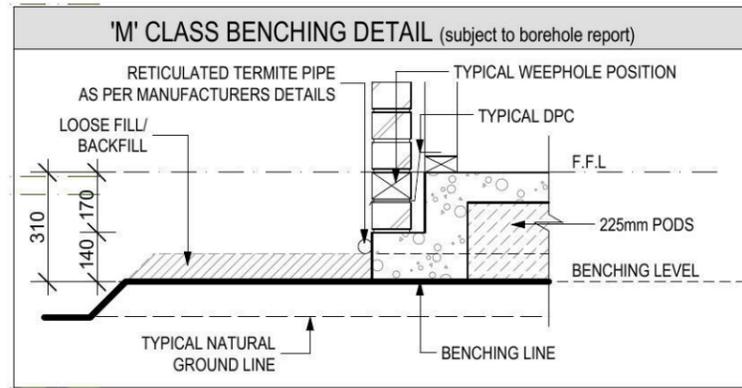

REAR/NORTH ELEVATION  
 1:100



RIGHT/EAST ELEVATION  
 1:100

**NOTES:**  
 \*REFER TO ENGINEERS DETAILS FOR ALL EXPANSION JOINT LOCATIONS.  
 \*REFER TO ENGINEERS DETAILS FOR ALL STEEL BEAM AND FLOOR JOIST LOCATIONS AND DIRECTIONS.  
 \*REFER TO TRUSS MANUFACTURERS DETAILS FOR ALL FLOOR JOIST SIZES AND DIRECTIONS.  
 \*REFER TO A/C DETAILS FOR A/C DUCT POSITIONS.  
 \*A/C DUCT LOCATIONS MAY NEED TO CHANGE DUE TO CONSTRUCTION REQUIREMENTS (JOIST LOCATION, STRUCTURAL BEAMS ETC).  
 \*FLOOR FINISHES AS SELECTED AS PER TENDER.



PROJECT:  
 PROPOSED TWO-STOREY BRICK VENEER DWELLING  
 ADDRESS:  
 Lot 2355 William Hart Crescent  
 Thornton Estate, Penrith  
 CLIENT:  
 Wisdom Homes Pty Ltd

LODGEMENT:  
 D.A/C.C  
 EXHAUST FAN  
 SMOKE DETECTOR. AS 3786-1993

NOTES: BOUNDARY SETBACKS MUST BE VERIFIED BY A REGISTERED SURVEYOR BEFORE COMMENCEMENT OF ANY BUILDING WORK. ALL WORK TO BE CARRIED OUT IN ACCORDANCE WITH THESE DRAWINGS, COUNCIL REQUIREMENTS, RELEVANT CODES & STANDARDS. LEVELS SHOWN ARE BASED ON CONTOUR SURVEY PREPARED BY A REGISTERED SURVEYOR. DRAWINGS ARE TO BE READ IN CONJUNCTION WITH SPECIFICATIONS PROVIDED & ENGINEERS DETAILS. WHERE ENGINEERS STRUCTURAL DRAWINGS ARE REQUIRED THE ENGINEERS PLAN WILL TAKE PREFERENCE TO THESE DRAWINGS. IN THE EVENT OF ANY ALTERATIONS OR DISCREPANCIES, NOTIFY WISDOM HOMES IMMEDIATELY. FIGURED DIMENSIONS TO BE READ IN PREFERENCE TO SCALING & TO BE CHECKED & VERIFIED BEFORE WORK IS COMMENCED.


REVISION SCHEDULE			
ISSUE	DESCRIPTION	DRAWN	DATE
A	CONTRACT PLAN	DC	25/02/14
A-1	CONTRACT AMENDMENTS	DC	10/03/14
A-2	CONTRACT AMENDMENTS	DC	27/03/14
B	DA PLANS	JH	13.05.14
B-1	PLAN AMENDMENTS	AS	14.08.14
-	-	-	-

JOB No:  
 003530  
 DATE:  
 25/02/14  
 LGA:  
 PENRITH  
 DESCRIPTION:  
 ABODE 27  
 CODE:  
 WH-ABOD27D CL LH

DRAWN:  
 DC  
 DATE:  
 25/02/14  
 SITE CLASSIFICATION:  
 'M' CLASS (subject to borehole report)  
 FACADE:  
 Classic  
 SHEET:  
 9

Window Schedule									
Window No.	Type	Window Size		Plan View	Elev. View	Glazing	Frame & Reveal	Flyscreens	Others
		Height	Width						
W1	AA2314T Special	2,040	1,440			Single Clear	240mm Brick veneer	-	-
W2	AF3010Special	3,000	1,000			Single Clear	240mm Brick veneer	-	-
W3	AS2027T Special	2,042	2,750			Single Clear	240mm Brick veneer	-	-
W4	AS2018T	2,042	1,791			Single Clear	240mm Brick veneer	-	-
W5	AS2018T	2,042	1,791			Single Clear	240mm Brick veneer	-	-
W6	AS2015T	2,042	1,500			Single Clear	240mm Brick veneer	-	-
W7	AAAF2023T Special	2,042	2,330			Single Clear	240mm Brick veneer	-	-
W8	AF2005 Special	2,042	300			Single Clear	90mm TF	-	-
W9	AF2005 Special	2,042	300			Single Clear	90mm TF	-	-
W10	AA1007	1,020	724			Single Obs.	240mm Brick veneer	-	-
W11	AS1224	1,191	2,391			Single Clear	90mm TF	-	-
W12	AA0607	600	724			Single Obs.	90mm TF	-	-
W13	AA1007	1,020	724			Single Obsc.	90mm TF	-	-
W14	AS1022	1,020	2,153			Single Clear	240mm Brick veneer	-	-
W15	AS1022	1,020	2,153			Single Clear	240mm Brick veneer	-	-
W16	AS1226	1,191	2,630			Single Clear	240mm Brick veneer	-	-
W17	AS1218	1,191	1,791			Single Clear	240mm Brick veneer	-	-

Door Schedule									
Door No.	Type	Door Size		Plan View	Elev. View	Glazing	Frame & Reveal	Flyscreens	Others
		Height	Width						
D1	MEF5	2,040	820			-	240mm Brick veneer	-	-
D2	MEF5	2,040	820			-	240mm Brick veneer	-	-
D3	TSD2032	2,065	3,195			Single Clear	240mm Brick veneer	-	-
D4	TXD2027	2,065	2,685			Single Clear	240mm Brick veneer	-	-
D5	TSD2032	2,065	2,652			Single Clear	240mm Brick veneer	-	-
D6	Int. 820mm hung door	2,040	820			-	90mm TF	-	-
D7	Int. 720mm hung door	2,040	720			-	90mm TF	-	-
D8	Int. 720mm hung door	2,040	1,040			-	90mm TF	-	-
D9	Int. 820mm hung door	2,040	820			-	90mm TF	-	-
D10	TXD2015	2,065	1,500			Single Clear	240mm Brick veneer	-	-
D11	Int. 820mm cavity sliding door	2,040	820			-	90mm TF	-	-
D12	Int. 820mm hung door	2,040	820			-	70mm TF	-	-
D13	Int. 820mm hung door	2,040	820			-	70mm TF	-	-
D14	Int. 820mm hung door	2,040	820			-	70mm TF	-	-
D15	Int. 770mm hung door	2,040	770			-	70mm TF	-	-
D16	Int. 820mm hung door	2,040	820			-	70mm TF	-	-
D17	Int. 820mm hung door	2,040	820			-	70mm TF	-	-

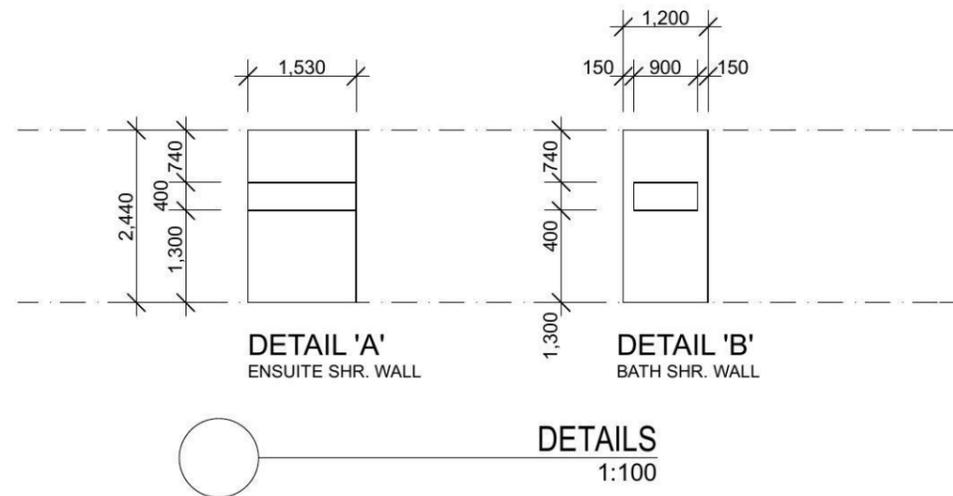

**NOTES:**  
 \*REFER TO ENGINEERS DETAILS FOR ALL EXPANSION JOINT LOCATIONS.  
 \*REFER TO ENGINEERS DETAILS FOR ALL STEEL BEAM AND FLOOR JOIST LOCATIONS AND DIRECTIONS.  
 \*REFER TO TRUSS MANUFACTURERS DETAILS FOR ALL FLOOR JOIST SIZES AND DIRECTIONS.  
 \*REFER TO A/C DETAILS FOR A/C DUCT POSITIONS.  
 \*A/C DUCT LOCATIONS MAY NEED TO CHANGE DUE TO CONSTRUCTION REQUIREMENTS (JOIST LOCATION, STRUCTURAL BEAMS ETC).  
 \*FLOOR FINISHES AS SELECTED AS PER TENDER.

**Wisdom Smart**

Ph: 4647 1200 Fax: 4647 1233

PROJECT:  
PROPOSED TWO-STOREY BRICK VENEER DWELLING

ADDRESS:  
Lot 2355 William Hart Crescent  
Thornton Estate, Penrith

CLIENT:  
Wisdom Homes Pty Ltd

LODGEMENT:  
D.A/C.C

- EXHAUST FAN
- SMOKE DETECTOR. AS 3786-1993




NOTES: BOUNDARY SETBACKS MUST BE VERIFIED BY A REGISTERED SURVEYOR BEFORE COMMENCEMENT OF ANY BUILDING WORK. ALL WORK TO BE CARRIED OUT IN ACCORDANCE WITH THESE DRAWINGS, COUNCIL REQUIREMENTS, RELEVANT CODES & STANDARDS. LEVELS SHOWN ARE BASED ON CONTOUR SURVEY PREPARED BY A REGISTERED SURVEYOR. DRAWINGS ARE TO BE READ IN CONJUNCTION WITH SPECIFICATIONS PROVIDED & ENGINEERS DETAILS. WHERE ENGINEERS STRUCTURAL DRAWINGS ARE REQUIRED THE ENGINEERS PLAN WILL TAKE PREFERENCE TO THESE DRAWINGS. IN THE EVENT OF ANY ALTERATIONS OR DISCREPANCIES, NOTIFY WISDOM HOMES IMMEDIATELY. FIGURED DIMENSIONS TO BE READ IN REFERENCE TO SCALING & TO BE CHECKED & VERIFIED BEFORE WORK IS COMMENCED.

REVISION SCHEDULE

ISSUE	DESCRIPTION	DRAWN	DATE
A	CONTRACT PLAN	DC	25/02/14
A-1	CONTRACT AMENDMENTS	DC	10/03/14
A-2	CONTRACT AMENDMENTS	DC	27/03/14
B	DA PLANS	JH	13.05.14
B-1	PLAN AMENDMENTS	AS	14.08.14
-	-	-	-

JOB No:  
**003530**  
 DATE:  
25/02/14  
 LGA:  
PENRITH  
 DESCRIPTION:  
ABODE 27  
 CODE:  
WH-ABOD27D CL LH

DRAWN:  
DC  
 DATE:  
25/02/14  
 SITE CLASSIFICATION:  
M' CLASS (subject to borehole report)  
 FACADE:  
Classic  
 SHEET:  
**11**

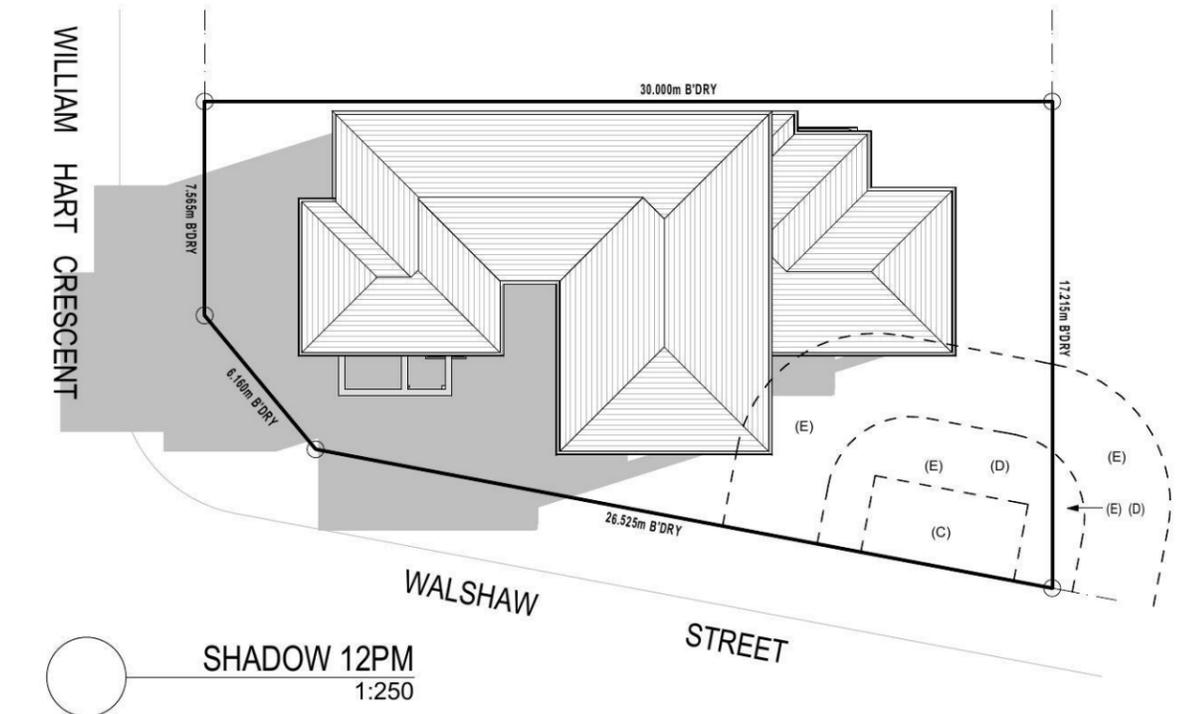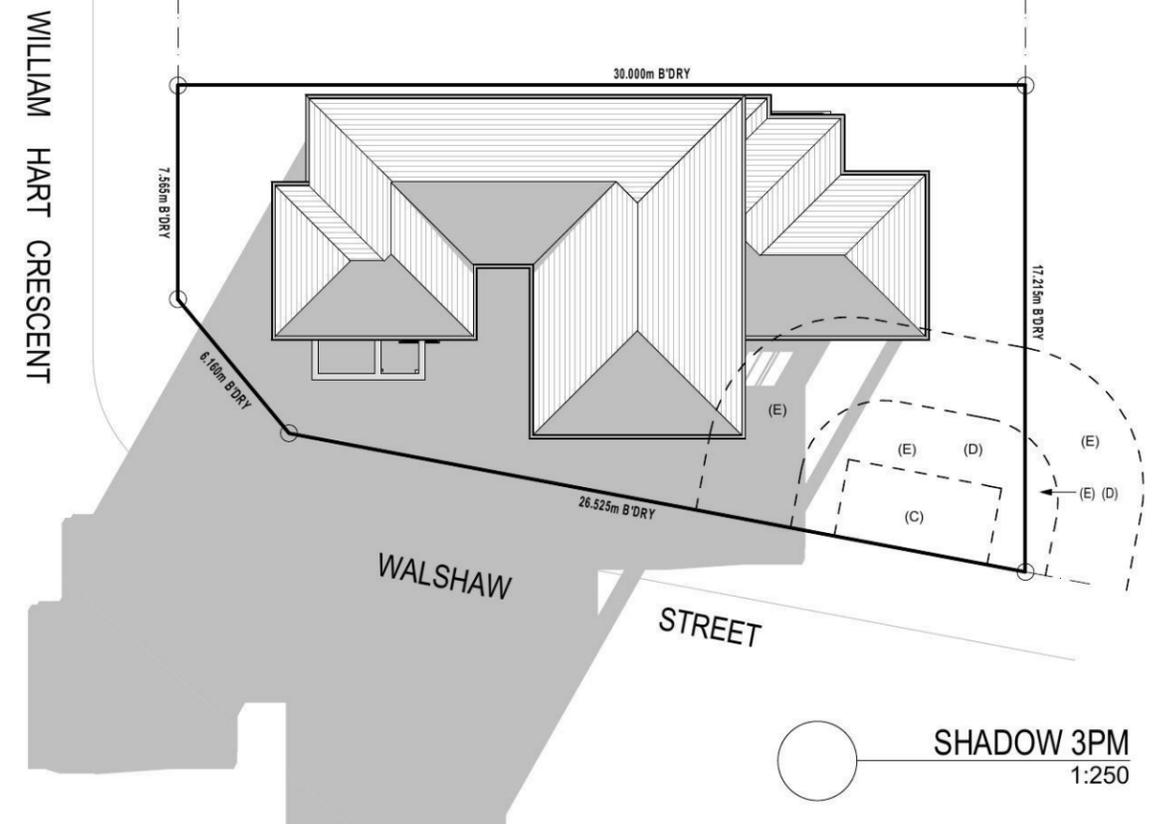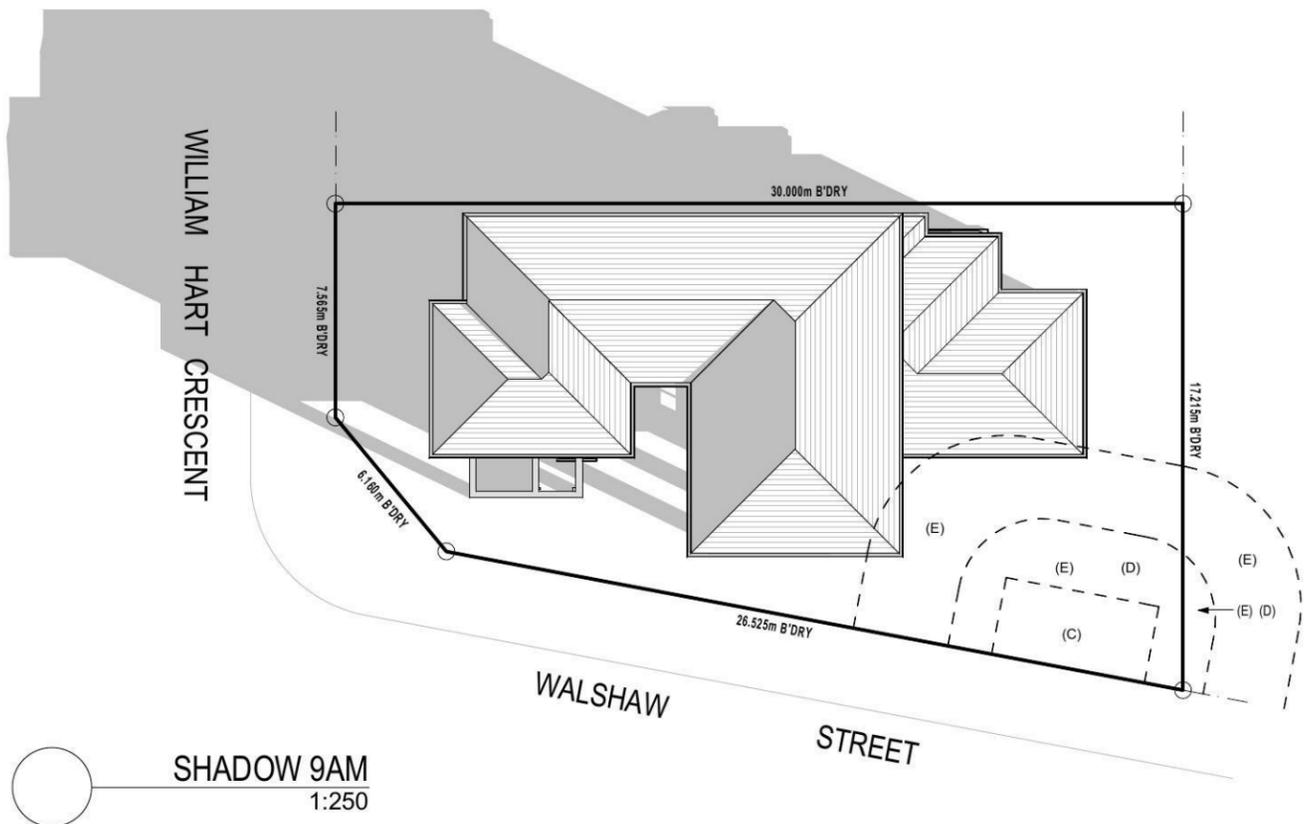

### SHADOW PROJECTIONS 21<sup>st</sup> JUNE

**NOTES:**  
 \*REFER TO ENGINEERS DETAILS FOR ALL EXPANSION JOINT LOCATIONS.  
 \*REFER TO ENGINEERS DETAILS FOR ALL STEEL BEAM AND FLOOR JOIST LOCATIONS AND DIRECTIONS.  
 \*REFER TO TRUSS MANUFACTURERS DETAILS FOR ALL FLOOR JOIST SIZES AND DIRECTIONS.  
 \*REFER TO A/C DETAILS FOR A/C DUCT POSITIONS.  
 \*A/C DUCT LOCATIONS MAY NEED TO CHANGE DUE TO CONSTRUCTION REQUIREMENTS (JOIST LOCATION, STRUCTURAL BEAMS ETC).  
 \*FLOOR FINISHES AS SELECTED AS PER TENDER.



PROJECT:  
 PROPOSED TWO-STOREY BRICK VENEER DWELLING  
 ADDRESS:  
 Lot 2355 William Hart Crescent  
 Thornton Estate, Penrith  
 CLIENT:  
 Wisdom Homes Pty Ltd

LODGEMENT:  
 D.A/C.C  
 EXHAUST FAN  
 SMOKE DETECTOR. AS 3786-1993

NOTES: BOUNDARY SETBACKS MUST BE VERIFIED BY A REGISTERED SURVEYOR BEFORE COMMENCEMENT OF ANY BUILDING WORK. ALL WORK TO BE CARRIED OUT IN ACCORDANCE WITH THESE DRAWINGS, COUNCIL REQUIREMENTS, RELEVANT CODES & STANDARDS. LEVELS SHOWN ARE BASED ON CONTOUR SURVEY PREPARED BY A REGISTERED SURVEYOR. DRAWINGS ARE TO BE READ IN CONJUNCTION WITH SPECIFICATIONS PROVIDED & ENGINEERS DETAILS. WHERE ENGINEERS STRUCTURAL DRAWINGS ARE REQUIRED THE ENGINEERS PLAN WILL TAKE PREFERENCE TO THESE DRAWINGS. IN THE EVENT OF ANY ALTERATIONS OR DISCREPANCIES, NOTIFY WISDOM HOMES IMMEDIATELY. FIGURED DIMENSIONS TO BE READ IN PREFERENCE TO SCALING & TO BE CHECKED & VERIFIED BEFORE WORK IS COMMENCED.

REVISION SCHEDULE			
ISSUE	DESCRIPTION	DRAWN	DATE
A	CONTRACT PLAN	DC	25/02/14
A-1	CONTRACT AMENDMENTS	DC	10/03/14
A-2	CONTRACT AMENDMENTS	DC	27/03/14
B	DA PLANS	JH	13.05.14
B-1	PLAN AMENDMENTS	AS	14.08.14
-	-	-	-

JOB No:  
 003530  
 LGA:  
 PENRITH  
 DESCRIPTION:  
 ABODE 27  
 CODE:  
 WH-ABOD27D CL LH

DRAWN:  
 DC  
 DATE:  
 25/02/14  
 SITE CLASSIFICATION:  
 'M' CLASS (subject to borehole report)  
 FACADE:  
 Classic  
 SHEET:  
 16