



Wood & Grieve Engineers now part of Stantec

Level 6, Building B, 207 Pacific Highway St Leonards NSW 2065

Tel: +61 2 8484 7000

Email: sydney@wge.com.au www.wge.com.au

Wood & Grieve Engineers Pty Limited ACN 137 999 609 trading as Wood & Grieve Engineers ABN 97 137 999 609



06 Feb 2020

Enquiries: Ian Harris Project No: 33696

RE: Hindu Temple - Kemps Creek

Bulk Earthworks

This letter has been prepared following our review of the updated development layout prepared by DDC architecture appended to this document.

We confirm that following review of the design and the impact on the bulk earthworks for the site we confirm that the cut/fill volumes of the site will be balanced.


We have reviewed the design from a civil engineering perspective and feel the design better responds to the existing topography of the site whilst providing a better development outcome.

Please do not hesitate to contact the undersigned if you have any queries.

Yours sincerely

Ian Harris


for Wood & Grieve Engineers now part of Stantec

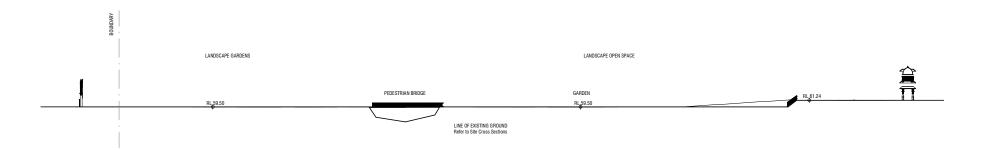

S4.55 - Site Section - Landscape



 $2^{\text{S4.55}}$ - Site Section - Central Facilities

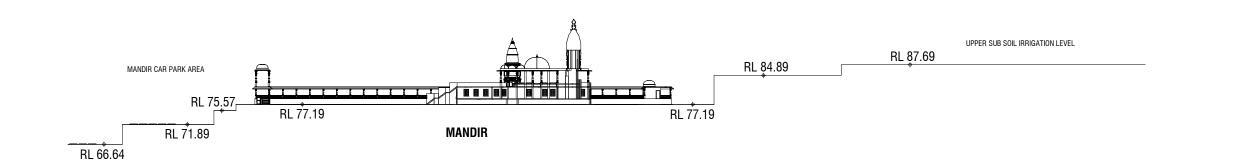

 $\mathbf{3}$ S4.55 - Site Section - Mandir

Document Set ID: 9121070 Version: 1, Version Date: 03/05/2020 THE NOMINATED RESPONSIBLE ARCHITECT FOR RALPH FERRIS AND SONS PYL LID TRADING AS DOE ARCHITECTURE + INTERIOR DESIGN IS GEOFF FERRIS-SMITH REGISTRATION 8334.

ACN: 145 390 389

REVISION SCHEDULE

ISSUE # DATE DESCRIPTION

TO BE READ IN CONJUNCTION WITH ENGINEER'S DOCUMENTS



DDC ARCHITECTURE + INTERIOR DESIGN

> Unit 3, 112 Russell Street Emu Plains NSW 2750

02 4728 6500 | ddc@jakaan.com.au

PROJECT TITLE

BAPS Temple

BAPS Swaminarayan Sa

ADDRESS Aldington Road, Kemps Creek

Kemps Creek

Site Sections

SCALE 1:500 @ A1

DRAWING NUMBER 19022 - I-100

28/01/2020 5:22:48 PM

SECTION 4.55

CONTRACTORS TO VERIFY ALL DIMENSIONS AND SETOUTS ON SITE BEFORE COMMENCING WORK.

TO BE READ IN CONJUNCTION WITH ENGINEER'S DOCUMENTS.

REVISION SCHEDULE		
ISSUE #	DATE	DESCRIPTION
1 28/01/20 Issue for Client		





DDC ARCHITECTURE + INTERIOR DESIGN

Unit 3, 112 Russell Street Emu Plains NSW 2750

02 4728 6500 | ddc@jakaan.com.au

PROJECT TITLE BAPS Temple

ADDRESS

Aldington Road, Kemps Creek

DRAWING TITLE Site Plan

1:1000@A1

19022 - I-101

28/01/2020 5:22:51 PM

SECTION 4.55

