





Tungsten

**ROOF TILE - BRISTILE
TUNGSTEN
SMOOTH PROFILE**

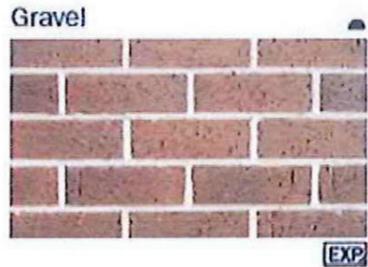

Gravel

**PGH BRICK
FOUNDATIONS
GRAVEL
Off White Mortar
Ironed Joints**

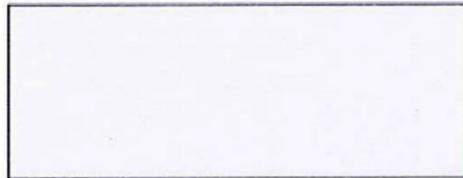


surf mist | matt
NOT AVAILABLE IN VIC & SA


**TREND WINDOWS
SURFMIST**



**DRIVEWAY- BLUESTONE
PLAIN COLOUR**

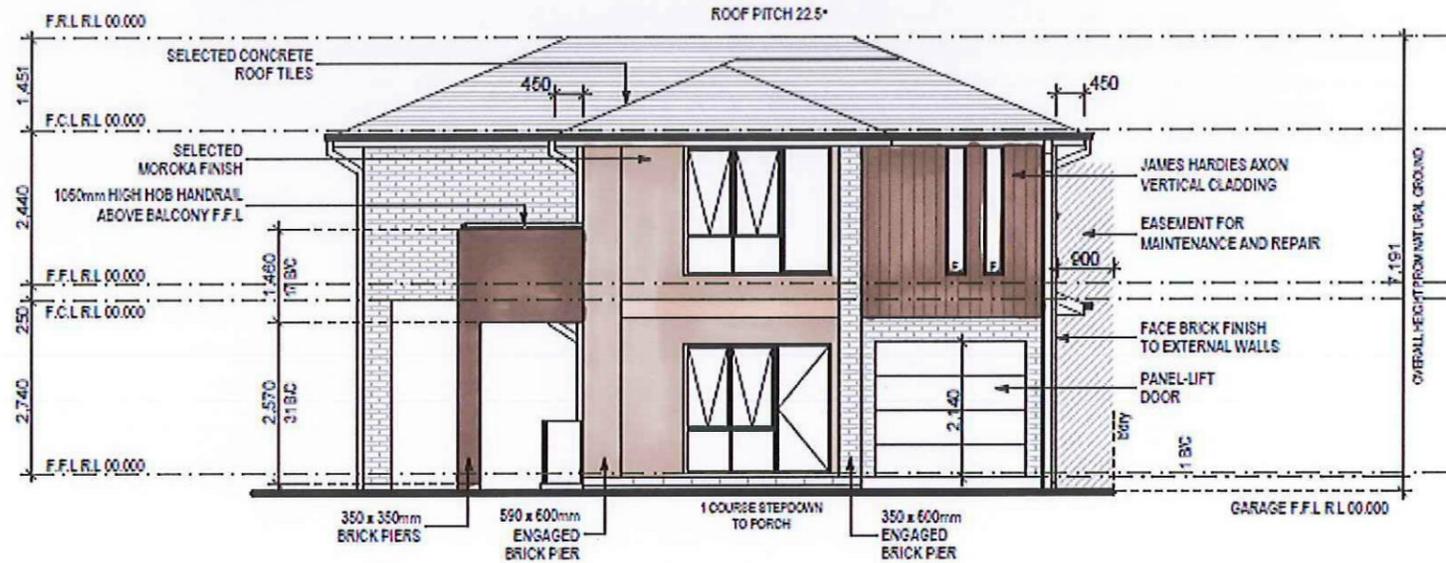

FRONT/SOUTH ELEVATION
1:100

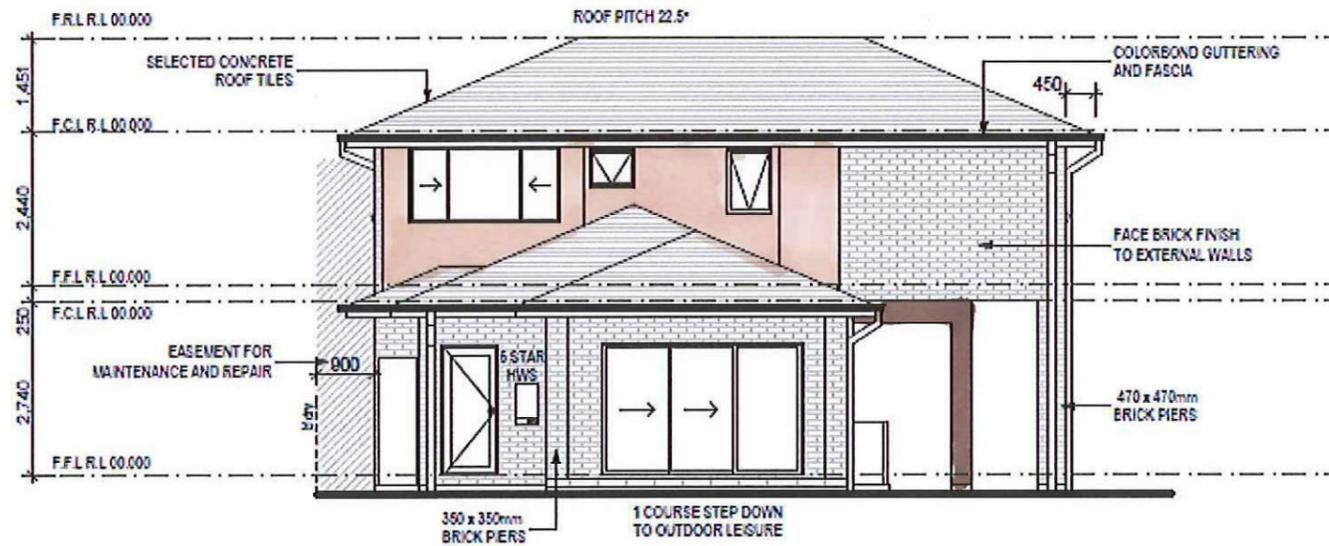

REAR/NORTH ELEVATION
1:100

COLORBOND - SURFMIST

- FRONT DOOR
- GARAGE DOOR


COLORBOND - MONUMENT

- GUTTER
- FASCIA
- BALCONY HANDRAIL
- METERBOX
- DOWNPIPES
- WATER TANK

**BRISTOL PAINT
HEARTHSTONE- CEMENT
RENDER TO BALCONY &
CLADDING**


**BRISTOL PAINT
DROVERS HAT- REMAINING
CEMENT RENDER &
BLUEBOARD**

	PROJECT: PROPOSED TWO-STOREY BRICK VENEER DWELLING	JOB No: 003535	DRAWN DC
	ADDRESS: Lot 2360 William Hart Crescent Thornton Estate, Penrith	LODGE MENT: D.A/C.C	DATE 25/02/14
CLIENT: Wisdom Homes Pty Ltd	<input checked="" type="checkbox"/> EXHAUST FAN <input checked="" type="checkbox"/> SMOKE DETECTOR. A3 3785-1593	LGA: PENRITH	SITE CLASSIFICATION M' CLASS
Ph: 4647 1200 Fax: 4647 1233 www.wisdomhomes.com.au	DESCRIPTION: ABODE 27	FAÇADE Classic	SHEET 5
		CODE: WH-ABOD27D CL RH	

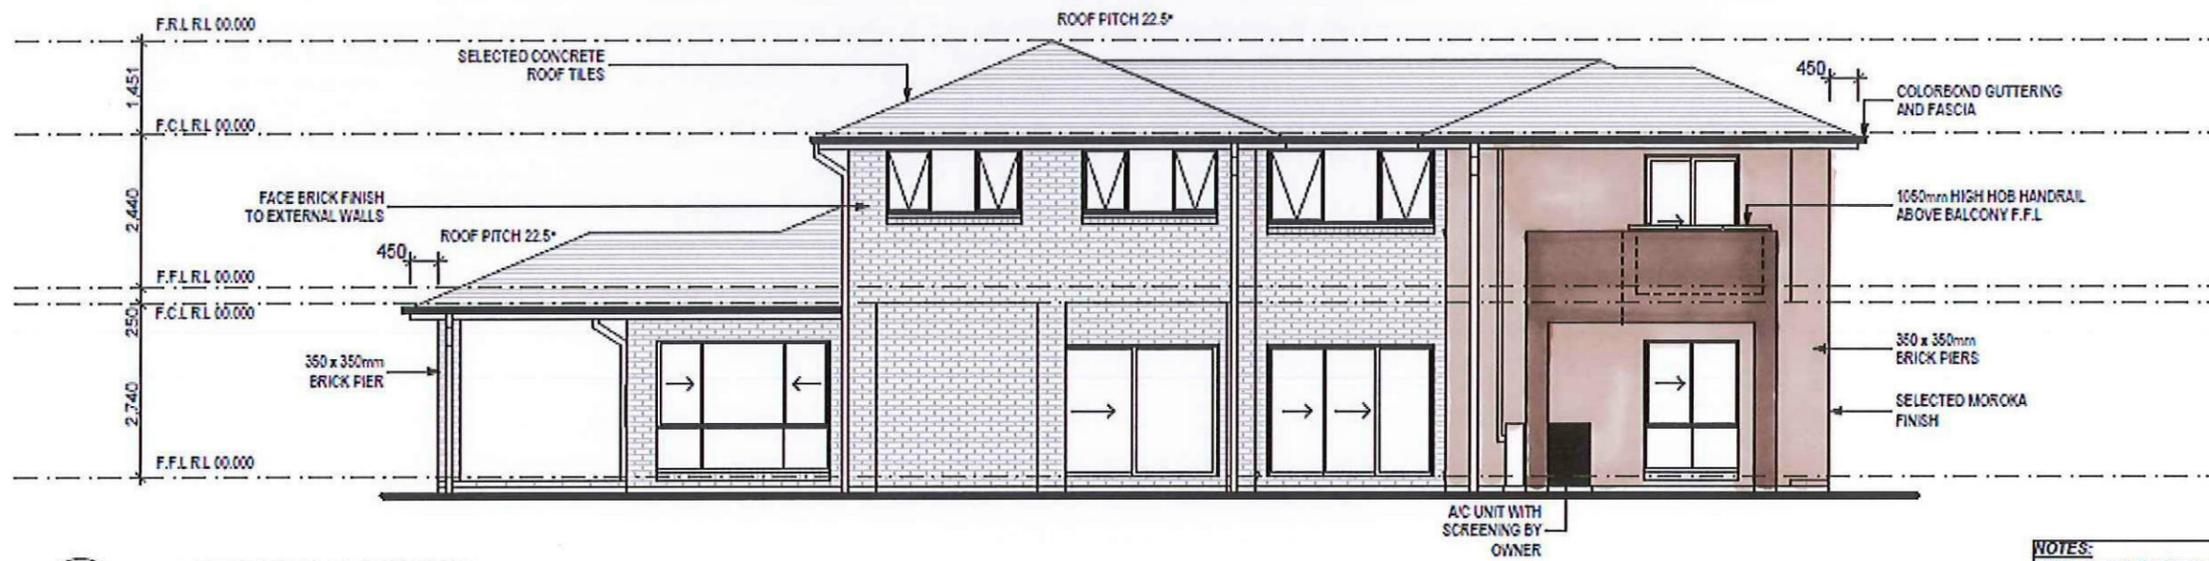

LEFT/WEST ELEVATION
1:100

NOTES:
REFER TO ENGINEERS DETAILS FOR
REFER TO ENGINEERS DETAILS FOR
LOCATIONS AND DIRECTIONS.
REFER TO TRUSS MANUFACTURER
DIRECTIONS.
REFER TO A/C DETAILS FOR A/C DET.

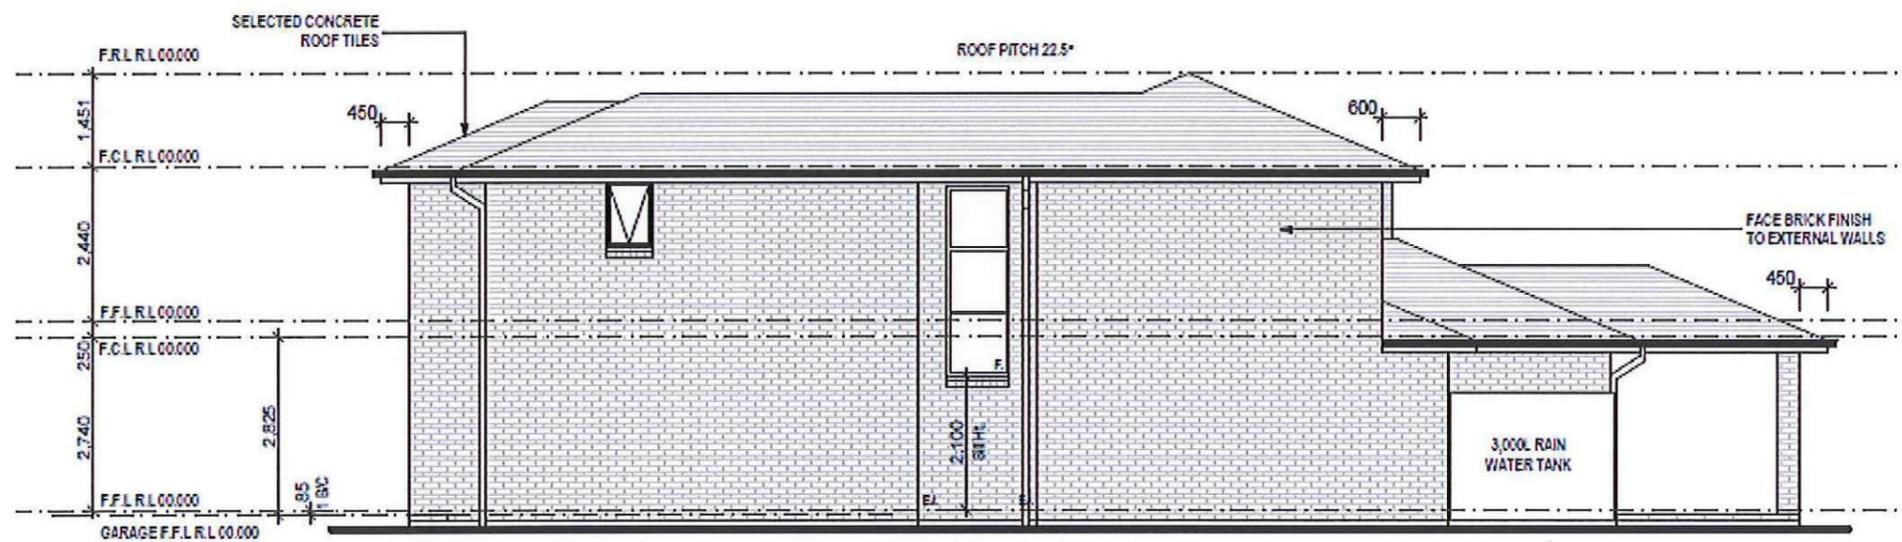

RIGHT/EAST ELEVATION
1:100

**Wisdom
Smart**

Ph: 4647 1200 Fax: 4647 1233
www.wisdomhomes.com.au

PROJECT:
PROPOSED TWO-STORY BRICK VENEER DWELLING

ADDRESS:
Lot 2360 William Hart Crescent
Thornton Estate, Penrith

CLIENT:
Wisdom Homes Pty Ltd

LODGEMENT:
D.A/C.C

EXHAUST FAN
SMOKE DETECTOR. AS 3785-1993

JOB No:
003535

DATE:
26/02/14

LGA:
PENRITH

DESCRIPTION:
ABODE 27

CODE:
WH-ABOD27D CL RH

DRAWN
DC
SITE CLASSIFICATION
M' CLASS (subject to council consent)
FACADE
Classic
SHEET

5






Lot 2360 William Hart

PLANT SCHEDULE Prepared by ecodesign Pty Ltd

SYMBOL	BOTANICAL NAME	COMMON NAME	QUANTITY	POT SIZE	MATURE SIZE
Aw	Agapanthus 'White'	White Agapanthus	27	200mm	0.5m
Dg	Dietes grandiflora	Wild Iris	12	200mm	1m
Fzk	Fraxinus omus 'Meczek'	Designer Flowering Ash	1	75L	5m
Gar	Gardenia augusta 'Radicans'	Rock Gardenia	10	200mm	0.5m
Vo	Viburnum odoratissimum	Sweet Viburnum	17	300mm	2.5m
Vh	Viola hederacea	Native Violet	36	150mm	0.1m

LOT PLANTING SUMMARY

Total Plants	Total Fence Hedging	Street Planting	Other Shrubs/ground-covers	Total Trees
103	17	27	59	1

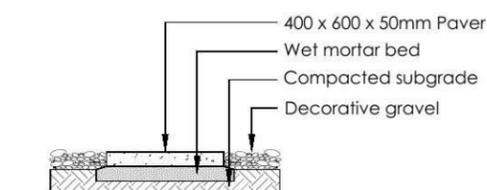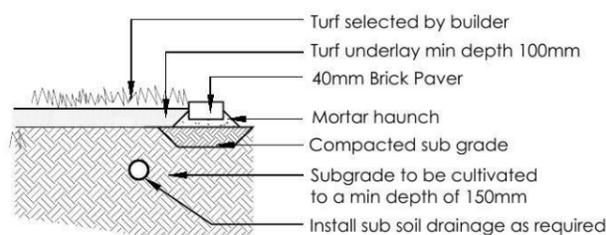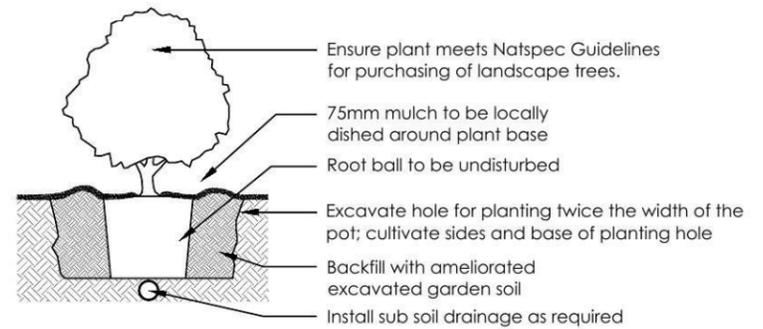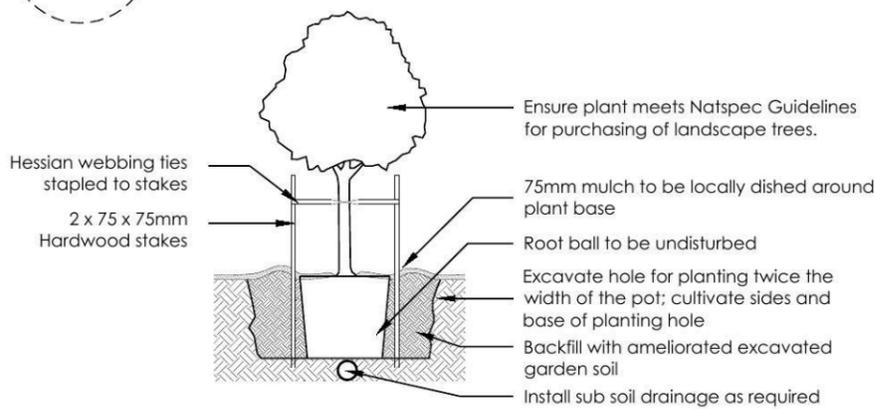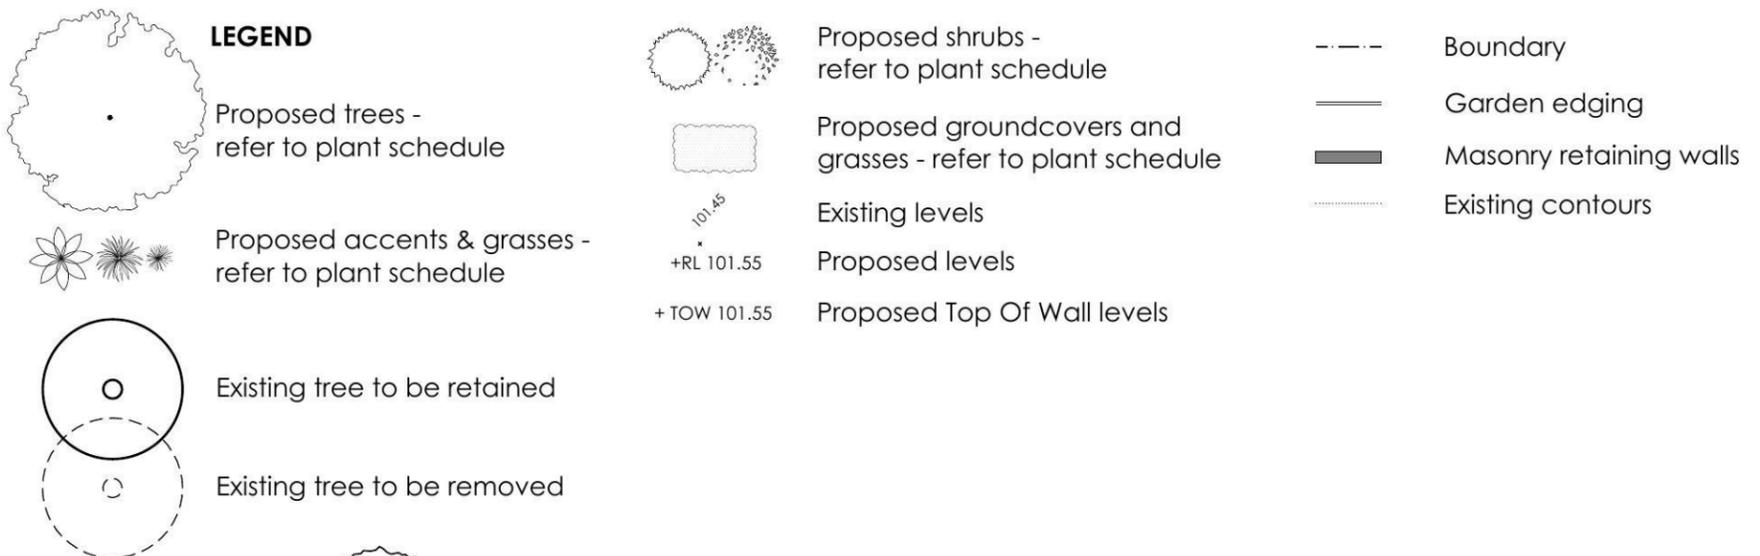

REVISION	DESCRIPTION	DRAWN	CHECK	DATE
A	ISSUE FOR CLIENT REVIEW	RS	BT	17-03-14
B	ADD STREET PLANTING ALONG TYPE 2A FENCING	RS	RS	18-03-14
C	AMEND FRONT FENCE TO TYPE 1B	RS	RS	23-05-14
D	UPDATE DA PLANS WITH NEW ARCHITECTURALS	RS	RS	05-09-14

ecodesign
outdoor living environments

PO Box 8136, Southam Hts BC, NSW 2153
Ph: (02) 9680 7712 Fax: (02) 9680 7705
Email: info@ecodesign.com.au
Web: www.ecodesign.com.au
Member of the Australian Institute of Landscape Designers and Managers


1. Do not scale from drawings.
2. Verify all measurements on site.
3. Notify ecodesign of any inconsistencies.
4. Copyright © ecodesign. All rights reserved.
5. Drawing remains the property of ecodesign.

6. All work to comply with relevant Australian Standards or Building Code of Australia.
7. All work to be performed by a suitably qualified tradesperson.
8. For application purposes only - NOT FOR CONSTRUCTION


ADDRESS	LOT 2360 WILLIAM HART CRESCENT, PENRITH
CLIENT	WISDOM HOMES

PROJECT	NEW RESIDENCE		
DRAWING	LANDSCAPE PLAN		
SCALE	1:100 @ A3	DATE	02
DRAWN	RS	CHECK	RS
DATE	05-09-14		REVISION
			D



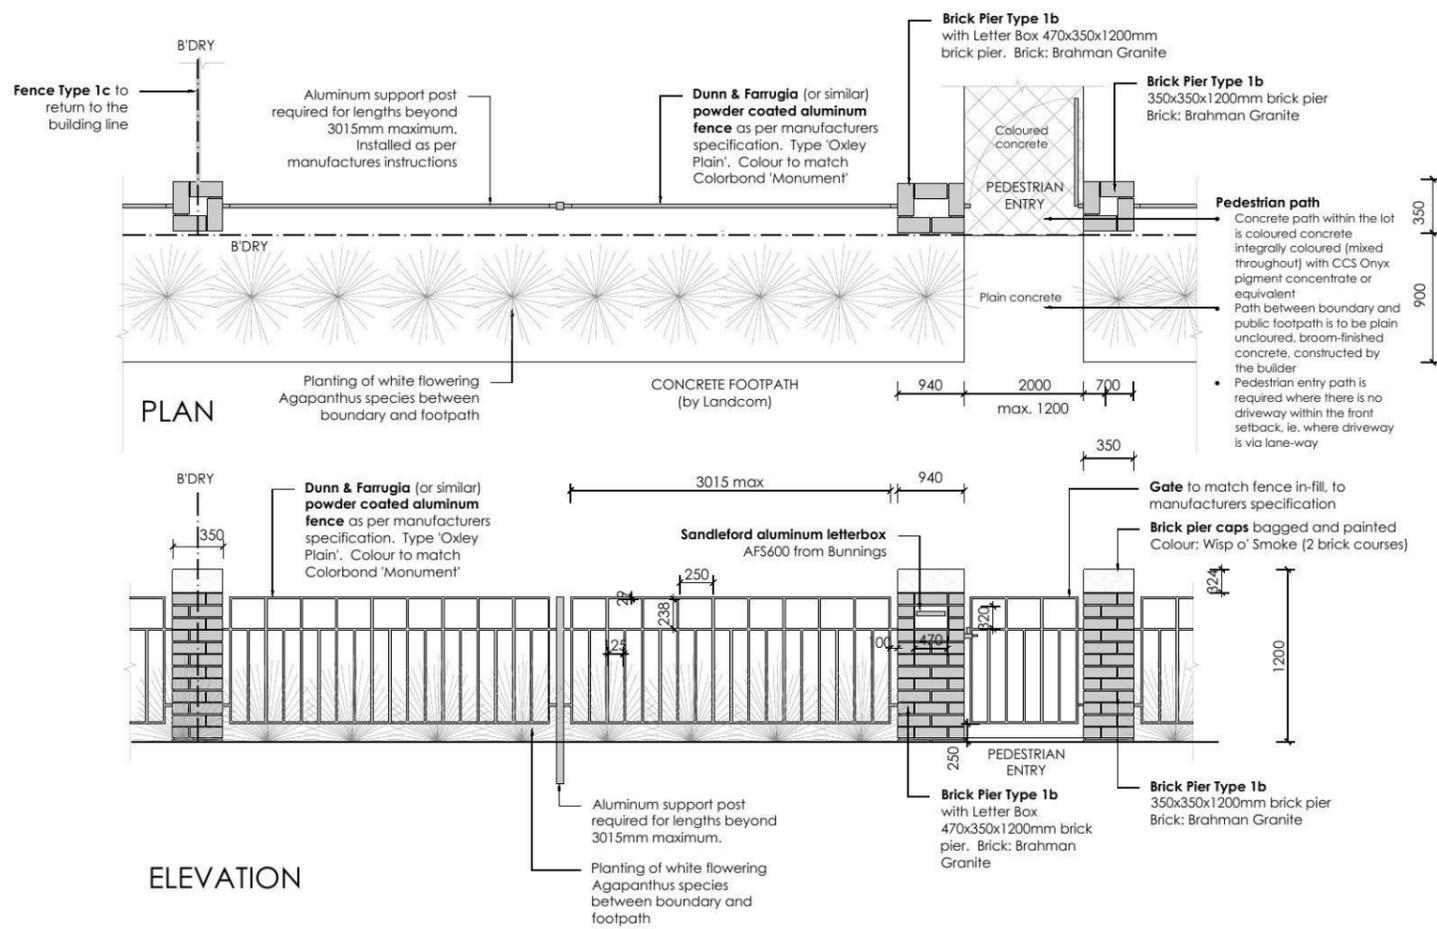

5 **FENCE TYPE 1b - Front Fence**
1:50 Typical detail

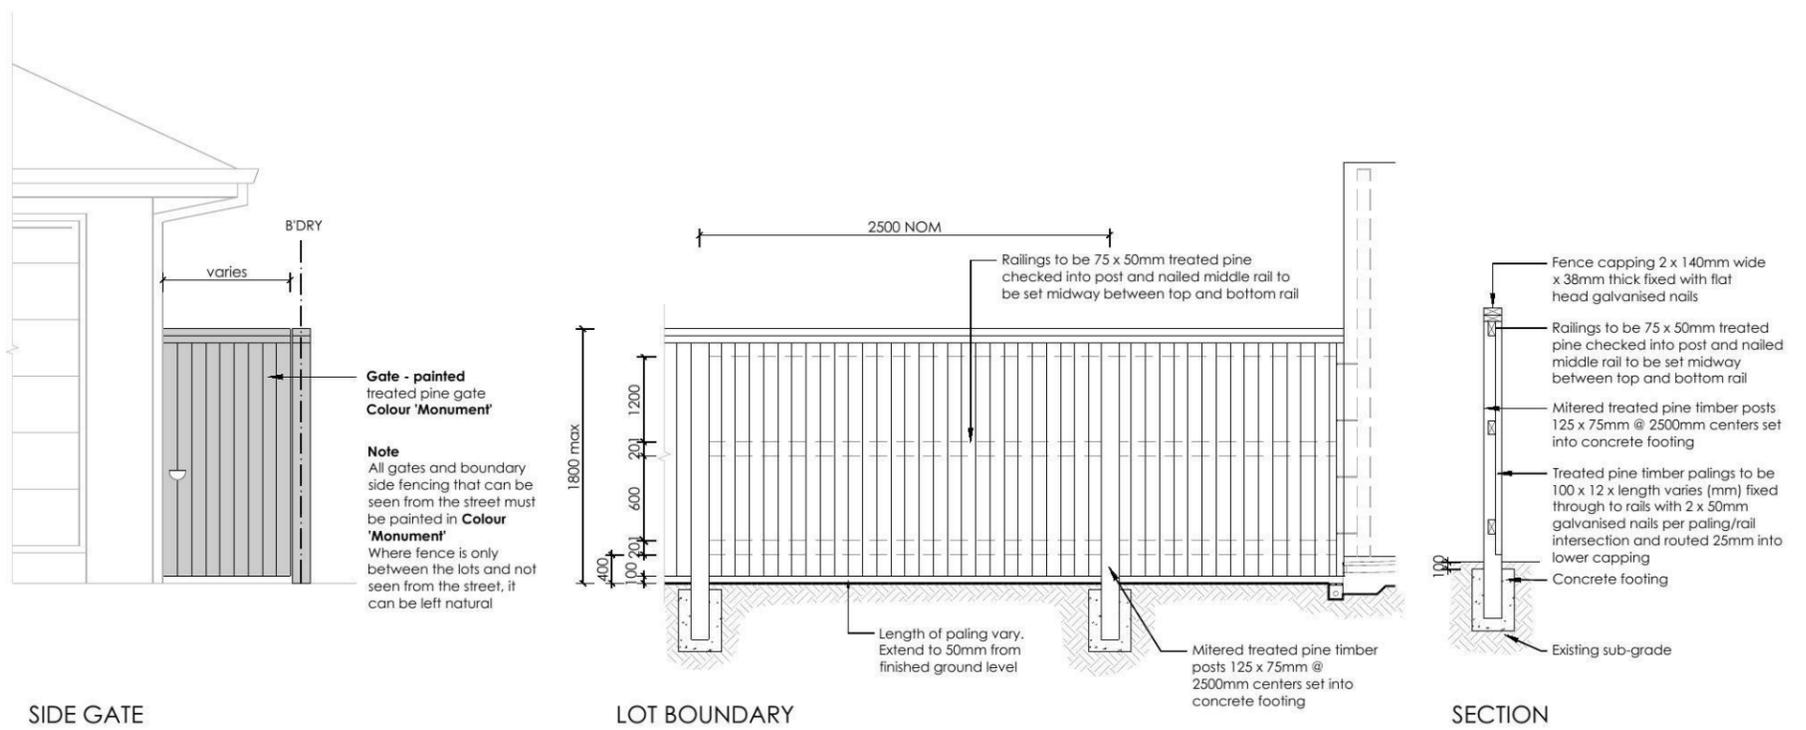

6 **FENCE TYPE 4a - Side Boundaries**
1:50 Typical detail

REVISION	DESCRIPTION	DRAWN	CHECK	DATE
A	ISSUE FOR CLIENT REVIEW	RS	BT	17-03-14
B	ADD STREET PLANTING ALONG TYPE 2A FENCING	RS	RS	18-03-14
C	AMEND FRONT FENCE TO TYPE 1B	RS	RS	23-05-14
D	UPDATE DA PLANS WITH NEW ARCHITECTURALS	RS	RS	05-09-14

ecodesign
outdoor living environments

PO Box 8136, Boulkham Hills BC, NSW 2153
Ph: (02) 9480 7712 Fax: (02) 9480 7705
Email: info@ecodesign.com.au
Web: www.ecodesign.com.au
Member of the Australian Institute of Landscape Designers and Managers

1. Do not scale from drawings.
2. Verify all measurements on site.
3. Notify ecodesign of any inconsistencies.
4. Copyright © ecodesign. All rights reserved.
5. Drawing remains the property of ecodesign.

6. All work to comply with relevant Australian Standards or Building Code of Australia.
7. All work to be performed by a suitably qualified tradesperson.
8. For application purposes only - NOT FOR CONSTRUCTION

PROJECT: **LOT 2360 WILLIAM HART CRESCENT, PENRITH**

CLIENT: **WISDOM HOMES**


PROJECT: **NEW RESIDENCE**

DRAWING: **LANDSCAPE PLAN**


SCALE: **1:100 @ A3** | TOUR: **DA** | SHEET: **03**

DRAWN: **RS** | CHECK: **RS** | DATE: **05-09-14** | REVISION: **D**



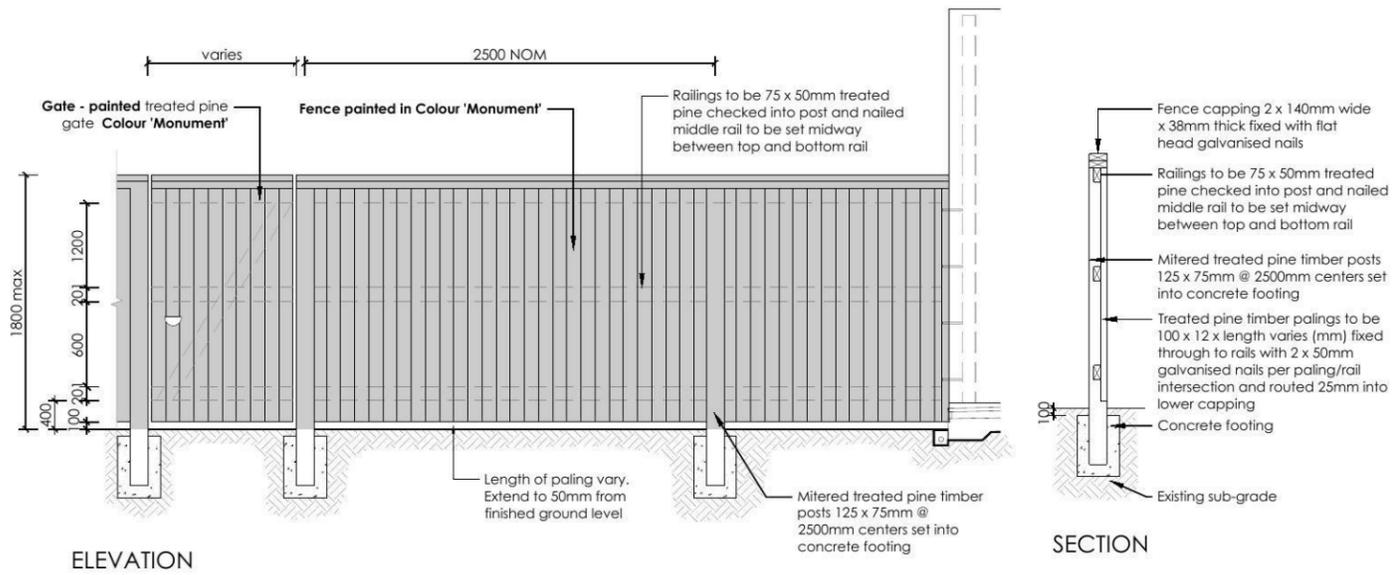

7 FENCE TYPE 4b - Rear Boundary
 1:50 All Laneways (except Barlett Lane)
 Typical detail

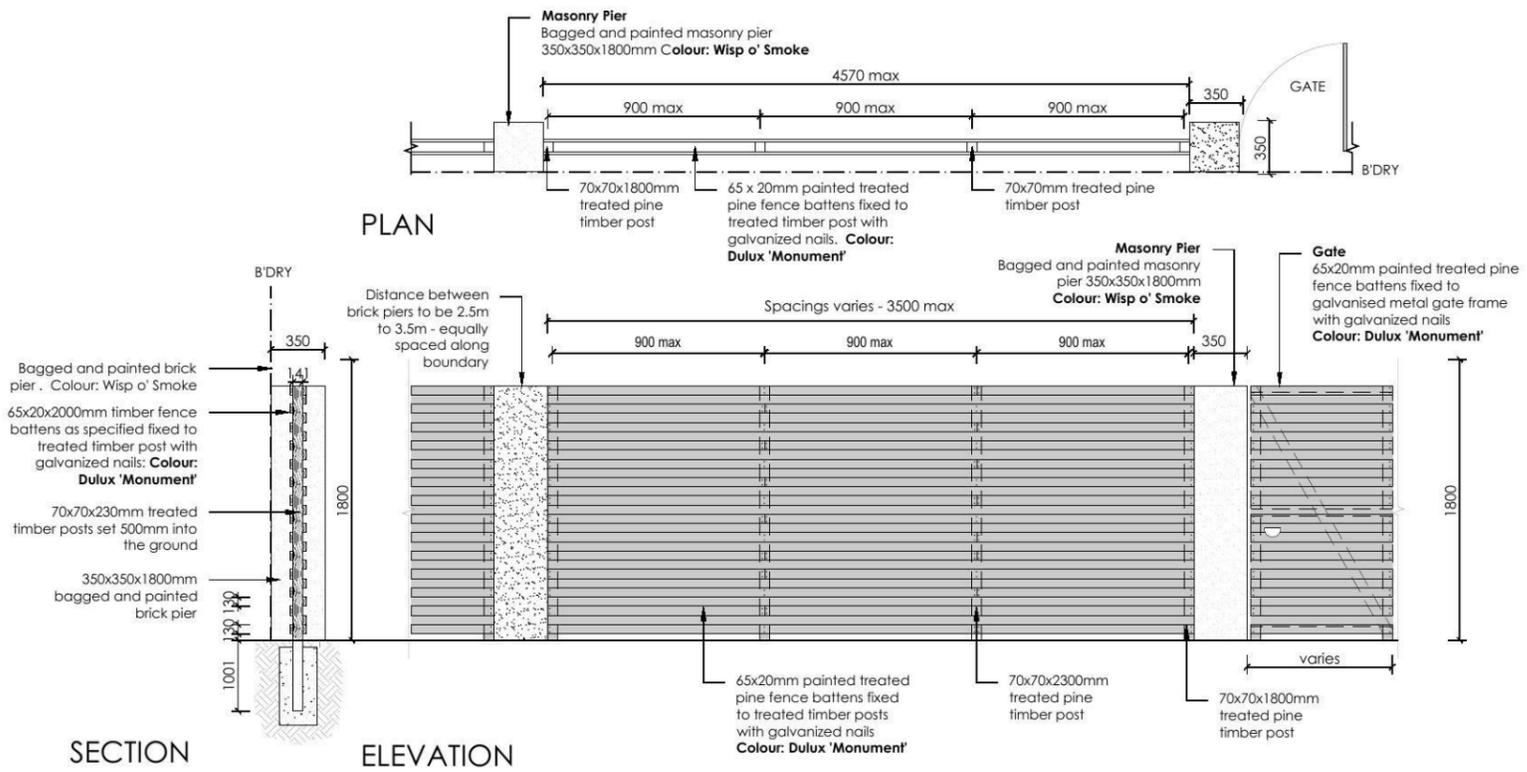

8 FENCE TYPE 2a - Secondary Street Fencing
 1:50 Typical detail

REVISION	DESCRIPTION	DRAWN	CHECK	DATE
A	ISSUE FOR CLIENT REVIEW	RS	BT	17-03-14
B	ADD STREET PLANTING ALONG TYPE 2A FENCING	RS	RS	18-03-14
C	AMEND FRONT FENCE TO TYPE 1B	RS	RS	23-05-14
D	UPDATE DA PLANS WITH NEW ARCHITECTURALS	RS	RS	05-09-14

ecodesign
 outdoor living environments

PO Box 8136, Baulkham Hills BC, NSW 2153
 Ph: (02) 9480 7712 Fax: (02) 9480 7705
 Email: info@ecodesign.com.au
 Web: www.ecodesign.com.au

Member of the Australian Institute of Landscape Designers and Managers

1. Do not scale from drawings.
 2. Verify all measurements on site.
 3. Notify ecodesign of any inconsistencies.
 4. Copyright © ecodesign. All rights reserved.
 5. Drawing remains the property of ecodesign.

6. All work to comply with relevant Australian Standards or Building Code of Australia.
 7. All work to be performed by a suitably qualified tradesperson.
 8. For application purposes only - NOT FOR CONSTRUCTION.

ADDRESS: **LOT 2360 WILLIAM HART CRESCENT, PENRITH**

CLIENT: **WISDOM HOMES**

PROJECT: **NEW RESIDENCE**

DRAWING: **LANDSCAPE PLAN**



SCALE: **1:100 @ A3** DATE: **DA** SHEET: **04**

DRAWN: **RS** CHECK: **RS** DATE: **05-09-14** REVISION: **D**



Abode 27 Classic

Page	Drawing
2	SITE PLAN
3	BENCHING PLAN
4	STORMWATER PLAN
5	SITE ANALYSIS PLAN
6	GROUND FLOOR PLAN
7	FIRST FLOOR PLAN
8	ELEVATIONS
9	ELEVATIONS
10	SECTIONS
11	WINDOW/DOOR SCHEDULE
12	ELECTRICAL PLAN
13	GROUND FLOOR WET AREA DETAILS
14	FIRST FLOOR WET AREA DETAILS
15	FIRST FLOOR WET AREA DETAILS
16	SHADOW DIAGRAMS

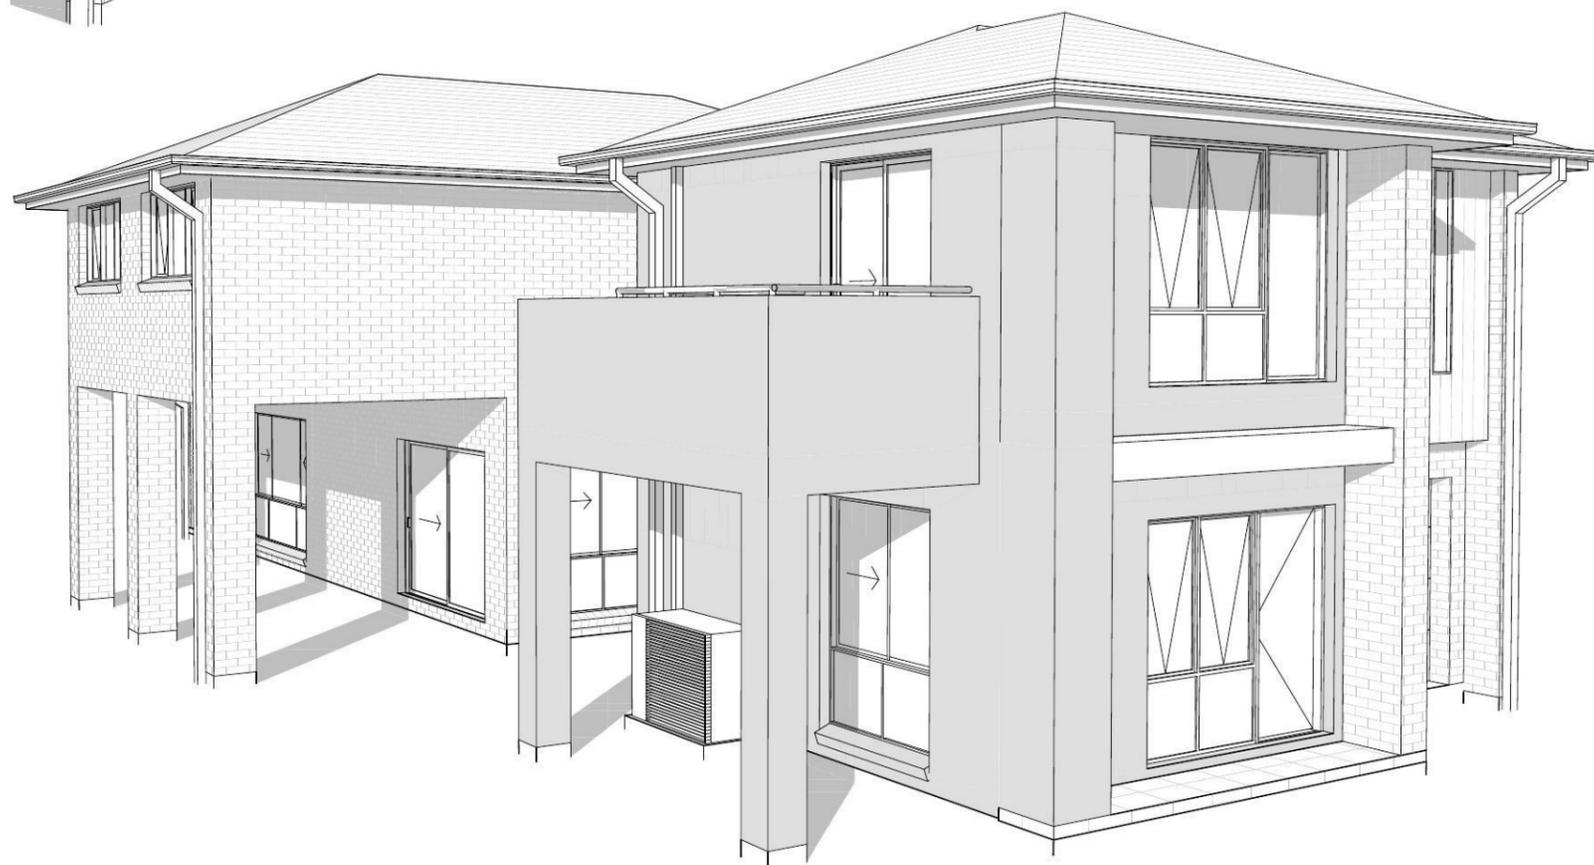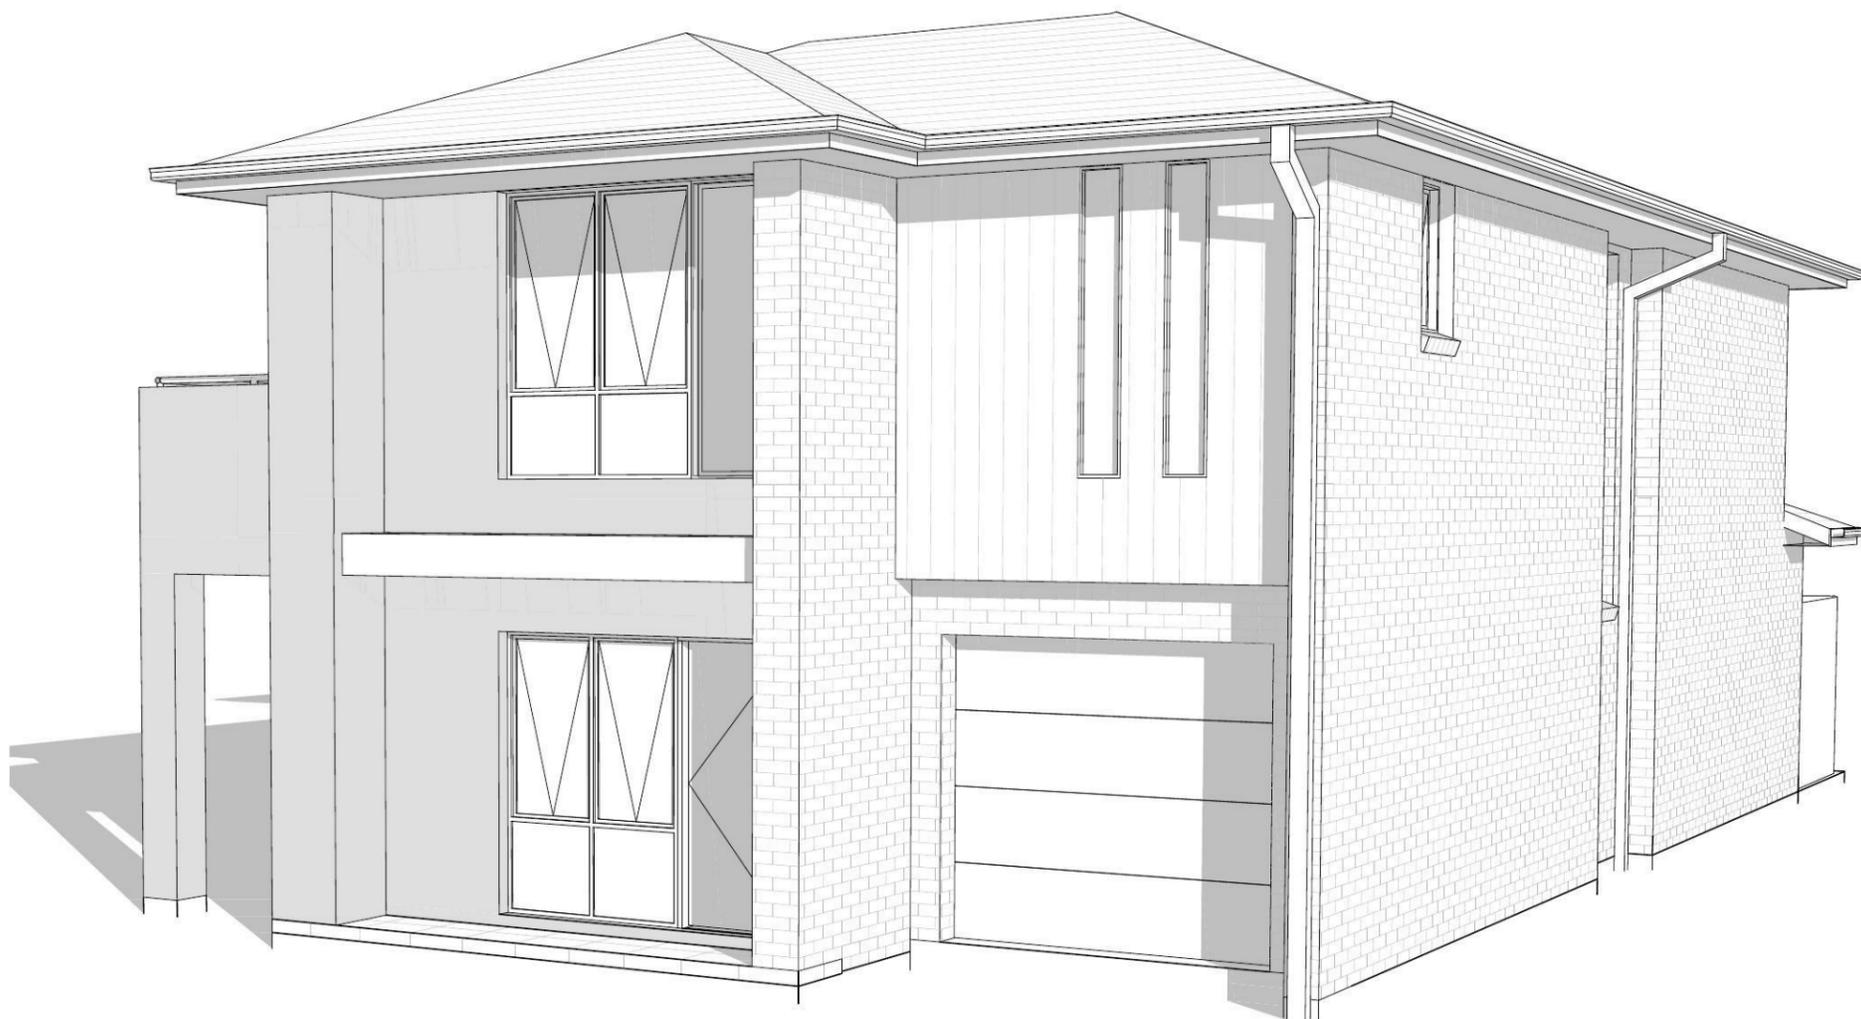

METRO
COLLECTION
by Wisdom

Ph: 4647 1200

Fax: 4647 1233

www.wisdomhomes.com.au

PROPOSED TWO-STOREY BRICK VENEER DWELLING

CLIENT:

Mr Y. SHI & Mrs J. Y. LIN

JOB No:

003535

ADDRESS:

**Lot 2360 William Hart Crescent
Thornton Estate, Penrith**

AREAS SCHEDULE

SITE DETAILS

LOT NUMBER: 2360
 SITE AREA: 382m²

DWELLING AREAS

GROUND FLOOR LIVING: 105.88m²
 FIRST FLOOR LIVING: 123.57m²
 GARAGE: 20.15m²
 PORCH: 2.65m²
 OUTDOOR LEISURE: 14.40m²
TOTAL FLOOR: 266.65m²

DRIVEWAY AND PATH AREA: 35.47m²

TOTAL ROOF AREA: 204.91m²
 (ROOF AREA TO R/WATER TANK AS PER BASIX CERTIFICATE)

SITE COVERAGE:
 PROPOSED: 179.45m² / 46.9%

FLOOR SPACE RATIO:
 PROPOSED: 229.45m² / 60%

LANDSCAPE RATIO:
 PROPOSED: 202.55m² / 53%

PRIVATE OPEN SPACE:
 (Min. 2m dimension)
 REQUIRED (min.): 76.40m² / 20%
 PROPOSED: 76.43m² / 20%

'M' CLASS

(subject to borehole report)

LOT: 2360
AREA: 382m²

STORMWATER DRAINAGE TO STREET.


EXCAVATE SITE APPROX. 000mm TO FORM JOB DATUM R.L 00.000 (ASSUMED) DATUM POINT 000mm BELOW FINISHED FLOOR LEVEL. EXTENT OF EXCAVATION AND BATTERS TO BE DETERMINED ON SITE.

(A) EASEMENT FOR MAINTENANCE AND SUPPORT 0.9 WIDE (ASSUMED)



WILLIAM HART CRESCENT

DURANT STREET

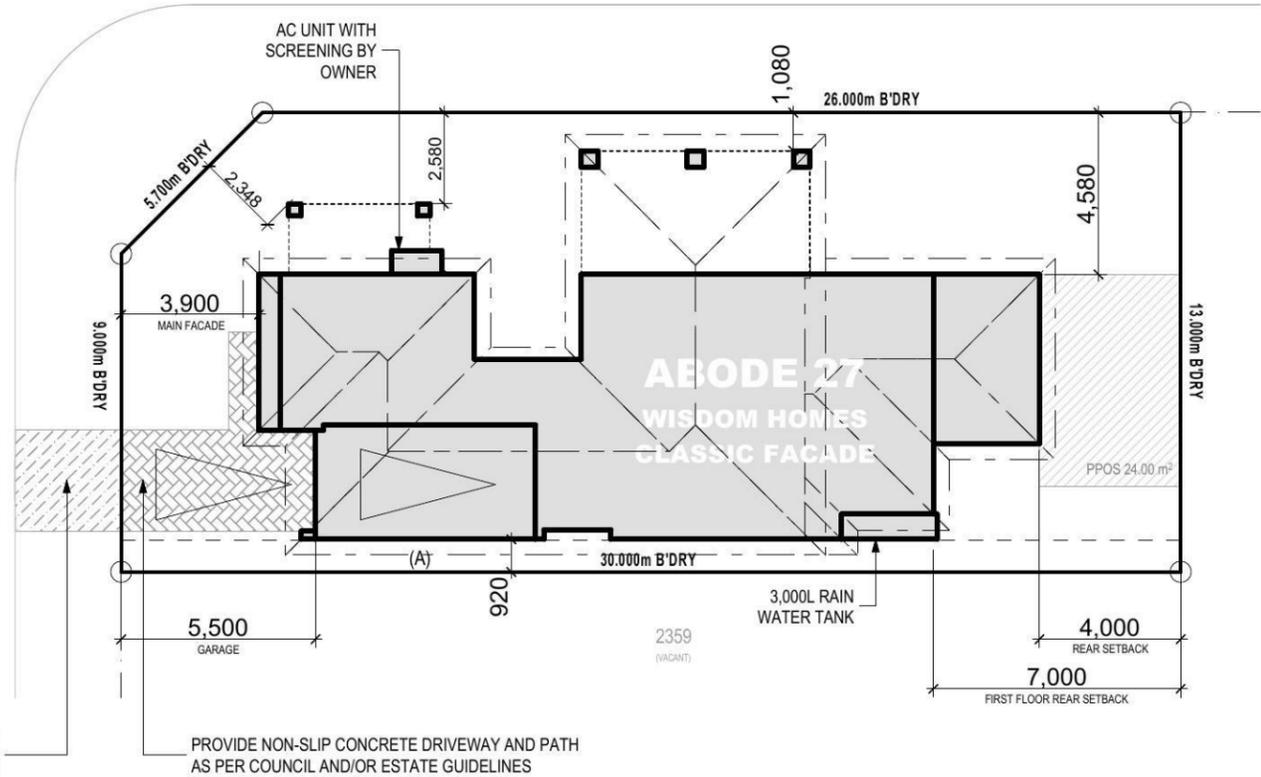

PROVIDE PLAIN CONCRETE TO CROSSOVER AS PER REQUIREMENTS

PROVIDE NON-SLIP CONCRETE DRIVEWAY AND PATH AS PER COUNCIL AND/OR ESTATE GUIDELINES

BASIX NOTES

WATER

- RAINWATER TANK OF AT LEAST 3,000 LITRES TO BE INSTALLED.
- RAINWATER TANK MUST MEET AND BE INSTALLED IN ACCORDANCE WITH APPLICABLE REGULATORY AUTHORITIES.
- RAINWATER TANK TO COLLECT RAIN RUNOFF FROM AT LEAST 204m² OF ROOF AREA.
- RAINWATER TANK SUPPLY TO BE CONNECT TO ALL TOILETS IN THE DEVELOPMENT.
- KITCHEN TAP FITTING RATING 4 STAR
- SHOWERHEAD RATING 3 STAR
- TOILET RATING (DUAL FLUSH) 4 STAR
- BATHROOM TAP FITTING RATING 6 STAR
- RAINWATER TANK TO BE CONNECTED TO AT LEAST ONE OUTDOOR TAP IN THE DEVELOPMENT.

THERMAL COMFORT

- EXTERNAL WALLS: BRICK VENEER/TIMBER FRAME
- EXTERNAL WALL INSULATION: R2.0
- EXTERNAL WALL COLOUR: MEDIUM
- ROOFING MATERIAL: CONCRETE ROOF TILES
- ROOF INSULATION: SARKING
- ROOF COLOUR: MEDIUM
- CEILING INSULATION: R3.5

ENERGY

- ACTIVE HEATING AND COOLING TO BE INSTALLED IN LIVING AND BEDROOMS, 3 PHASE A/C SYSTEM (EER 2.5-3.0). TO BE DAY/NIGHT ZONED BETWEEN LIVING AREAS AND BEDROOMS. TO BE INSTALLED PRIOR TO FINAL OCCUPATION CERTIFICATE.
- PROVIDE GAS 6 STAR INSTANTANEOUS HWS.
- PROVIDE GAS COOKTOP TO KITCHEN.
- PROVIDE ELECTRIC OVEN TO KITCHEN.
- ALL REFRIGERATOR SPACES TO BE WELL VENTILATED.
- PROVIDE COMPACT FLUORESCENT ENERGY SAVING LIGHT BULBS TO ALL LIGHT POINTS.
- PROVIDE OUTDOOR CLOTHES LINE BY OWNER.

SITE PLAN

1:200

NOTES:

- *REFER TO ENGINEERS DETAILS FOR ALL EXPANSION JOINT LOCATIONS.
- *REFER TO ENGINEERS DETAILS FOR ALL STEEL BEAM AND FLOOR JOIST LOCATIONS AND DIRECTIONS.
- *REFER TO TRUSS MANUFACTURERS DETAILS FOR ALL FLOOR JOIST SIZES AND DIRECTIONS.
- *REFER TO A/C DETAILS FOR A/C DUCT POSITIONS.
- *A/C DUCT LOCATIONS MAY NEED TO CHANGE DUE TO CONSTRUCTION REQUIREMENTS (JOIST LOCATION, STRUCTURAL BEAMS ETC).
- *FLOOR FINISHES AS SELECTED AS PER TENDER.

PROJECT: PROPOSED TWO-STOREY BRICK VENEER DWELLING

ADDRESS: Lot 2360 William Hart Crescent
 Thornton Estate, Penrith

CLIENT: Mr Y. SHI & Mrs J. Y. LIN

LODGEMENT: D.A/C.C

- ⊗ EXHAUST FAN
- ⊗ SMOKE DETECTOR. AS 3786-1993

NOTES: BOUNDARY SETBACKS MUST BE VERIFIED BY A REGISTERED SURVEYOR BEFORE COMMENCEMENT OF ANY BUILDING WORK. ALL WORK TO BE CARRIED OUT IN ACCORDANCE WITH THESE DRAWINGS, COUNCIL REQUIREMENTS, RELEVANT CODES & STANDARDS. LEVELS SHOWN ARE BASED ON CONTOUR SURVEY PREPARED BY A REGISTERED SURVEYOR. DRAWINGS ARE TO BE READ IN CONJUNCTION WITH SPECIFICATIONS PROVIDED & ENGINEERS DETAILS. WHERE ENGINEERS STRUCTURAL DRAWINGS ARE REQUIRED THE ENGINEERS PLAN WILL TAKE PREFERENCE TO THESE DRAWINGS. IN THE EVENT OF ANY ALTERATIONS OR DISCREPANCIES, NOTIFY WISDOM HOMES IMMEDIATELY. FIGURED DIMENSIONS TO BE READ IN PREFERENCE TO SCALING & TO BE CHECKED & VERIFIED BEFORE WORK IS COMMENCED.

REVISION SCHEDULE


ISSUE	DESCRIPTION	DRAWN	DATE
A	CONTRACT PLAN	DC	25/02/14
A-1	AMENDED CONTRACT PLAN	DC	10/03/14
B	DA PLANS	AS	13/05/14
B-1	PLAN AMENDMENTS	AS	15/08/14
B-2	WINDOW AMENDMENTS	AS	20.08.14
-	-	-	-

JOB No: 003535
 DATE: 25/02/14
 LGA: PENRITH
 DESCRIPTION: ABODE 27
 CODE: WH-ABOD27D CL RH

DRAWN: DC
 DATE: 25/02/14
 SITE CLASSIFICATION: 'M' CLASS (subject to borehole report)
 FACADE: Classic
 SHEET: 2



Ph: 4647 1200
 Fax: 4647 1233
 www.wisdomhomes.com.au
 *COPYRIGHT OF PLANS AND DOCUMENTATION REMAIN THE EXCLUSIVE PROPERTY OF WISDOM PROPERTIES GROUP PTY LTD T/A WISDOM HOMES. BUILDERS LIC. No 131951C.

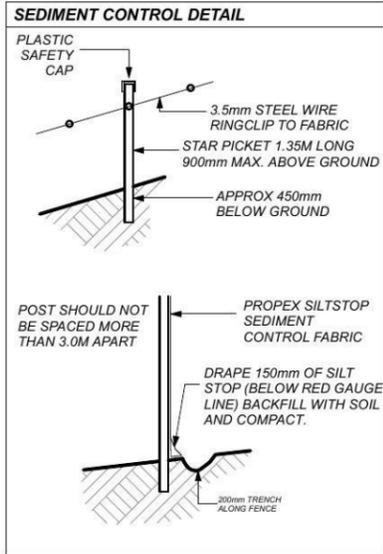

ANY RETAINING WALLS REQUIRED TO BE COMPLETED BY OWNERS TO MANUFACTURERS SPECIFICATIONS.

PROVIDE 1.80m HIGH SECURITY FENCE TO PERIMETER OF SITE AS PER COUNCIL REQUIREMENTS.

PROVIDE TEMPORARY STABILISED VEHICLE ACCESS DRIVEWAY (GRAVEL/ROCK AGGREGATE)

PROVIDE SEDIMENT CONTROL FENCE AS PER COUNCIL REQUIREMENTS.


 
'M' CLASS
(subject to borehole report)

LOT: 2360
AREA: 382m²

STORMWATER DRAINAGE TO STREET.

EXCAVATE SITE APPROX. 000mm TO FORM JOB DATUM R.L 00.000 (ASSUMED) DATUM POINT 000mm BELOW FINISHED FLOOR LEVEL. EXTENT OF EXCAVATION AND BATTERS TO BE DETERMINED ON SITE.

(A) EASEMENT FOR MAINTENANCE AND SUPPORT 0.9 WIDE (ASSUMED)

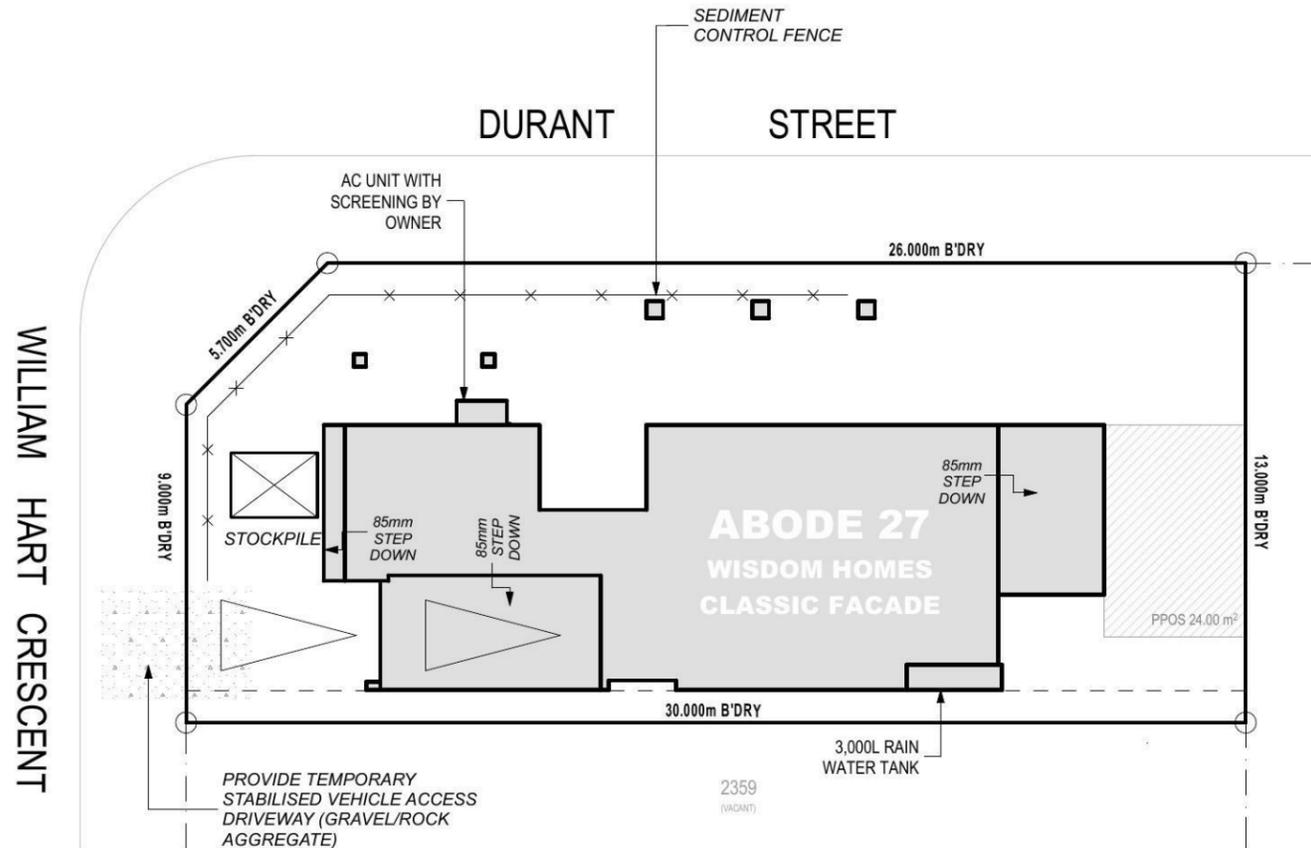

BENCHING PLAN
1:200

NOTES:
 *REFER TO ENGINEERS DETAILS FOR ALL EXPANSION JOINT LOCATIONS.
 *REFER TO ENGINEERS DETAILS FOR ALL STEEL BEAM AND FLOOR JOIST LOCATIONS AND DIRECTIONS.
 *REFER TO TRUSS MANUFACTURERS DETAILS FOR ALL FLOOR JOIST SIZES AND DIRECTIONS.
 *REFER TO A/C DETAILS FOR A/C DUCT POSITIONS.
 *A/C DUCT LOCATIONS MAY NEED TO CHANGE DUE TO CONSTRUCTION REQUIREMENTS (JOIST LOCATION, STRUCTURAL BEAMS ETC).
 *FLOOR FINISHES AS SELECTED AS PER TENDER.



	Ph: 4647 1200 Fax: 4647 1233 www.wisdomhomes.com.au	PROJECT: PROPOSED TWO-STOREY BRICK VENEER DWELLING	NOTES: BOUNDARY SETBACKS MUST BE VERIFIED BY A REGISTERED SURVEYOR BEFORE COMMENCEMENT OF ANY BUILDING WORK. ALL WORK TO BE CARRIED OUT IN ACCORDANCE WITH THESE DRAWINGS, COUNCIL REQUIREMENTS, RELEVANT CODES & STANDARDS. LEVELS SHOWN ARE BASED ON CONTOUR SURVEY PREPARED BY A REGISTERED SURVEYOR. DRAWINGS ARE TO BE READ IN CONJUNCTION WITH SPECIFICATIONS PROVIDED & ENGINEERS DETAILS. WHERE ENGINEERS STRUCTURAL DRAWINGS ARE REQUIRED THE ENGINEERS PLAN WILL TAKE PREFERENCE TO THESE DRAWINGS. IN THE EVENT OF ANY ALTERATIONS OR DISCREPANCIES, NOTIFY WISDOM HOMES IMMEDIATELY. FIGURED DIMENSIONS TO BE READ IN PREFERENCE TO SCALING & TO BE CHECKED & VERIFIED BEFORE WORK IS COMMENCED.	REVISION SCHEDULE		JOB No: 003535	DRAWN: DC
	*COPYRIGHT OF PLANS AND DOCUMENTATION REMAIN THE EXCLUSIVE PROPERTY OF WISDOM PROPERTIES GROUP PTY LTD T/A WISDOM HOMES. BUILDERS LIC. No 131951C.	ADDRESS: Lot 2360 William Hart Crescent Thornton Estate, Penrith		LODGEMENT: D.A/C.C	ISSUE DESCRIPTION DRAWN DATE	LGA: PENRITH	DATE: 25/02/14
	CLIENT: Mr Y. SHI & Mrs J. Y. LIN	EXHAUST FAN SMOKE DETECTOR. AS 3786-1993		A CONTRACT PLAN DC 25/02/14	DESCRIPTION: ABODE 27	FACADE: Classic	
				A-1 AMENDED CONTRACT PLAN DC 10/03/14	CODE: WH-ABOD27D CL RH	SHEET: 3	
				B DA PLANS AS 13/05/14			
				B-1 PLAN AMENDMENTS AS 15/08/14			
				B-2 WINDOW AMENDMENTS AS 20.08.14			
				- - - -			


'M' CLASS
(subject to borehole report)

LOT: 2360
AREA: 382m²

STORMWATER DRAINAGE TO STREET.

EXCAVATE SITE APPROX. 000mm TO FORM JOB DATUM R.L. 00.000 (ASSUMED) DATUM POINT 000mm BELOW FINISHED FLOOR LEVEL. EXTENT OF EXCAVATION AND BATTERS TO BE DETERMINED ON SITE.

(A) EASEMENT FOR MAINTENANCE AND SUPPORT 0.9 WIDE (ASSUMED)

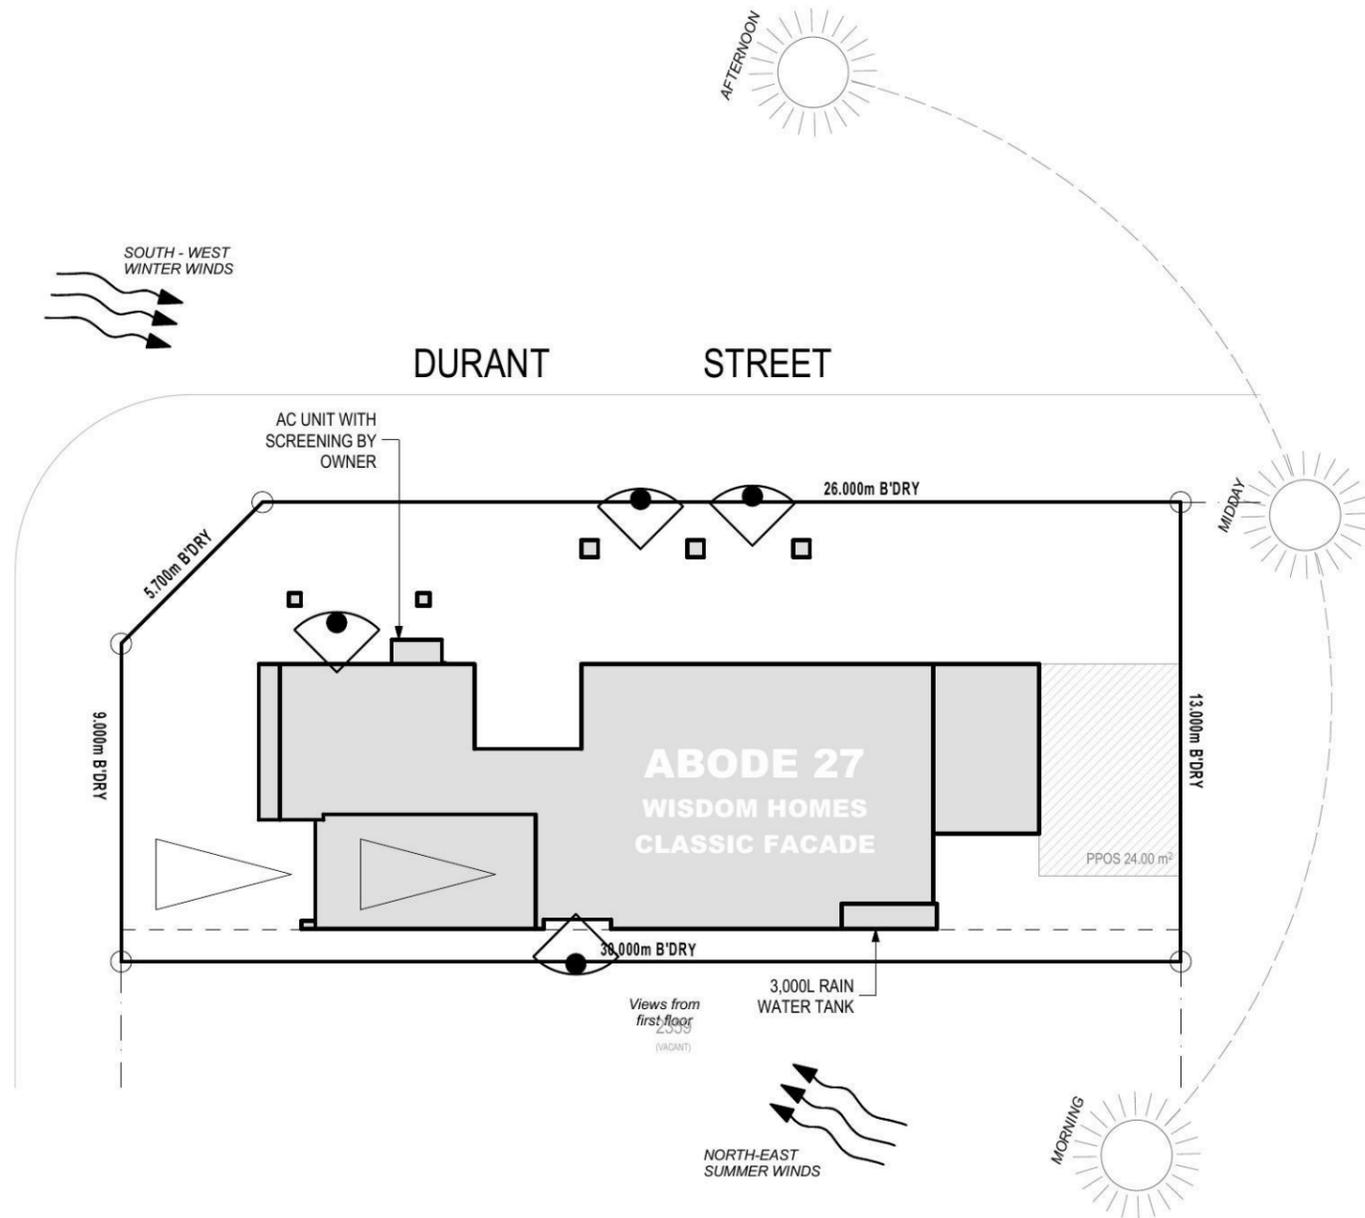

SITE ANALYSIS PLAN
1:200

NOTES:
*REFER TO ENGINEERS DETAILS FOR ALL EXPANSION JOINT LOCATIONS.
*REFER TO ENGINEERS DETAILS FOR ALL STEEL BEAM AND FLOOR JOIST LOCATIONS AND DIRECTIONS.
*REFER TO TRUSS MANUFACTURERS DETAILS FOR ALL FLOOR JOIST SIZES AND DIRECTIONS.
*REFER TO A/C DETAILS FOR A/C DUCT POSITIONS.
*A/C DUCT LOCATIONS MAY NEED TO CHANGE DUE TO CONSTRUCTION REQUIREMENTS (JOIST LOCATION, STRUCTURAL BEAMS ETC).
*FLOOR FINISHES AS SELECTED AS PER TENDER.


PROJECT: PROPOSED TWO-STOREY BRICK VENEER DWELLING	NOTES: BOUNDARY SETBACKS MUST BE VERIFIED BY A REGISTERED SURVEYOR BEFORE COMMENCEMENT OF ANY BUILDING WORK. ALL WORK TO BE CARRIED OUT IN ACCORDANCE WITH THESE DRAWINGS, COUNCIL REQUIREMENTS, RELEVANT CODES & STANDARDS. LEVELS SHOWN ARE BASED ON CONTOUR SURVEY PREPARED BY A REGISTERED SURVEYOR. DRAWINGS ARE TO BE READ IN CONJUNCTION WITH SPECIFICATIONS PROVIDED & ENGINEERS DETAILS. WHERE ENGINEERS STRUCTURAL DRAWINGS ARE REQUIRED THE ENGINEERS PLAN WILL TAKE PREFERENCE TO THESE DRAWINGS. IN THE EVENT OF ANY ALTERATIONS OR DISCREPANCIES, NOTIFY WISDOM HOMES IMMEDIATELY. FIGURED DIMENSIONS TO BE READ IN PREFERENCE TO SCALING & TO BE CHECKED & VERIFIED BEFORE WORK IS COMMENCED.
ADDRESS: Lot 2360 William Hart Crescent Thornton Estate, Penrith	LODGE MENT: D.A/C.C
CLIENT: Mr Y. SHI & Mrs J. Y. LIN	<input checked="" type="checkbox"/> EXHAUST FAN <input checked="" type="checkbox"/> SMOKE DETECTOR. AS 3786-1993

REVISION SCHEDULE			
ISSUE	DESCRIPTION	DRAWN	DATE
A	CONTRACT PLAN	DC	25/02/14
A-1	AMENDED CONTRACT PLAN	DC	10/03/14
B	DA PLANS	AS	13/05/14
B-1	PLAN AMENDMENTS	AS	15/08/14
B-2	WINDOW AMENDMENTS	AS	20.08.14
-	-	-	-


JOB No: 003535	DRAWN: DC
DATE: 25/02/14	SITE CLASSIFICATION: 'M' CLASS (subject to borehole report)
LGA: PENRITH	FACADE: Classic
DESCRIPTION: ABODE 27	SHEET: 5
CODE: WH-ABOD27D CL RH	

Ph: 4647 1200
Fax: 4647 1233
www.wisdomhomes.com.au

*COPYRIGHT OF PLANS AND DOCUMENTATION REMAIN THE EXCLUSIVE PROPERTY OF WISDOM PROPERTIES GROUP PTY LTD T/A WISDOM HOMES. BUILDERS LIC. No 131951C.

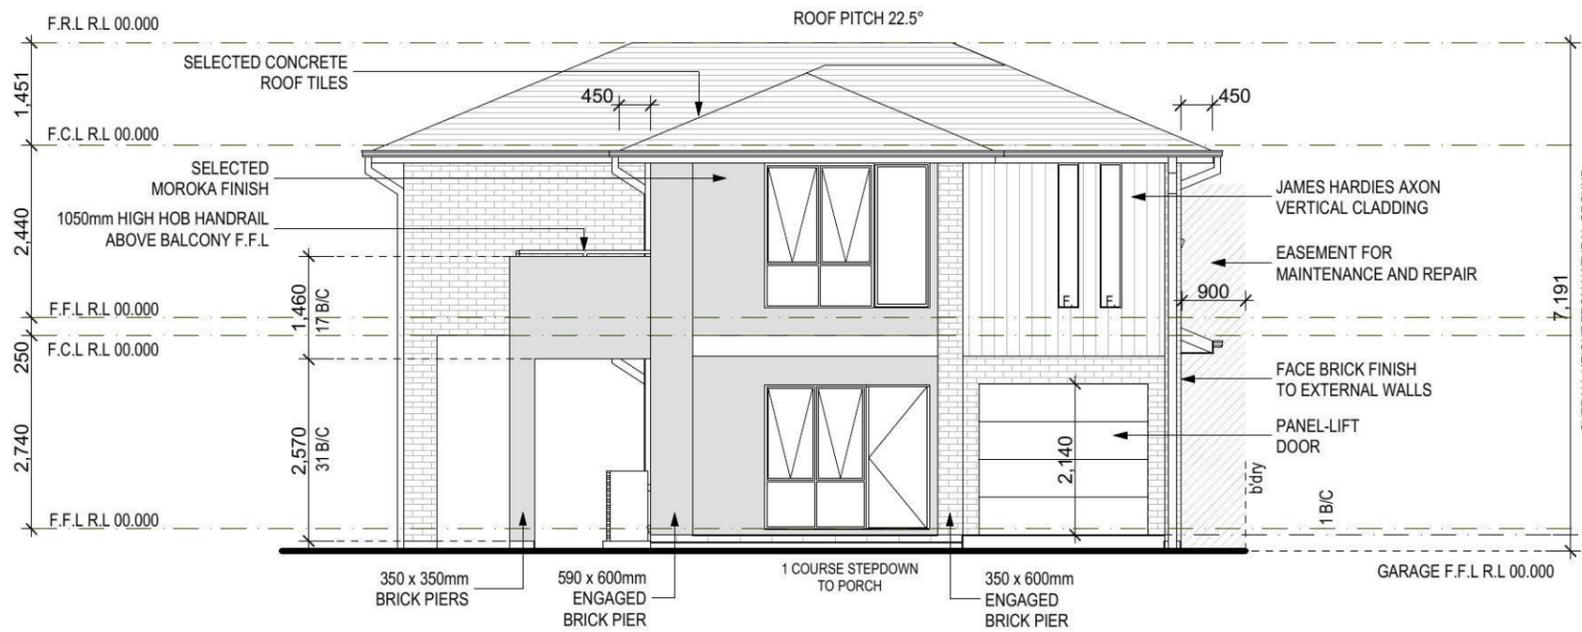

NOTE:
 OPENABLE TO BE IN ACCORANCE WITH CLAUSE 3.9.2.5 OF THE BCA 2013 VOL. 2 -
 FIRST FLOOR WINDOWS TO BE RESTRICTED TO OPEN A MAX. OF 125mm
 IF SILL HEIGHT IS LOWER THAN 1700mm ABOVE A FLOOR LEVEL.

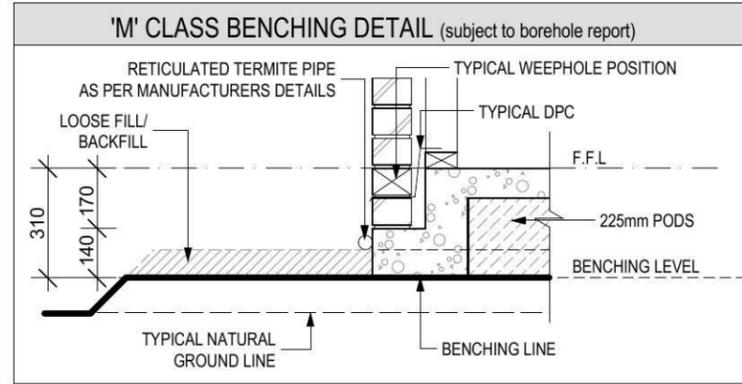

FRONT/SOUTH ELEVATION
 1:100



LEFT/WEST ELEVATION
 1:100

NOTES:
 *REFER TO ENGINEERS DETAILS FOR ALL EXPANSION JOINT LOCATIONS.
 *REFER TO ENGINEERS DETAILS FOR ALL STEEL BEAM AND FLOOR JOIST LOCATIONS AND DIRECTIONS.
 *REFER TO TRUSS MANUFACTURERS DETAILS FOR ALL FLOOR JOIST SIZES AND DIRECTIONS.
 *REFER TO A/C DETAILS FOR A/C DUCT POSITIONS.
 *A/C DUCT LOCATIONS MAY NEED TO CHANGE DUE TO CONSTRUCTION REQUIREMENTS (JOIST LOCATION, STRUCTURAL BEAMS ETC).
 *FLOOR FINISHES AS SELECTED AS PER TENDER.

PROJECT:
 PROPOSED TWO-STOREY BRICK VENEER DWELLING

ADDRESS:
 Lot 2360 William Hart Crescent
 Thornton Estate, Penrith

CLIENT:
 Mr Y. SHI & Mrs J. Y. LIN

LODGEMENT:
 D.A/C.C

- ⊗ EXHAUST FAN
- ⊗ SMOKE DETECTOR. AS 3786-1993

NOTES: BOUNDARY SETBACKS MUST BE VERIFIED BY A REGISTERED SURVEYOR BEFORE COMMENCEMENT OF ANY BUILDING WORK. ALL WORK TO BE CARRIED OUT IN ACCORDANCE WITH THESE DRAWINGS, COUNCIL REQUIREMENTS, RELEVANT CODES & STANDARDS. LEVELS SHOWN ARE BASED ON CONTOUR SURVEY PREPARED BY A REGISTERED SURVEYOR. DRAWINGS ARE TO BE READ IN CONJUNCTION WITH SPECIFICATIONS PROVIDED & ENGINEERS DETAILS. WHERE ENGINEERS STRUCTURAL DRAWINGS ARE REQUIRED THE ENGINEERS PLAN WILL TAKE PREFERENCE TO THESE DRAWINGS. IN THE EVENT OF ANY ALTERATIONS OR DISCREPANCIES, NOTIFY WISDOM HOMES IMMEDIATELY. FIGURED DIMENSIONS TO BE READ IN PREFERENCE TO SCALING & TO BE CHECKED & VERIFIED BEFORE WORK IS COMMENCED.

REVISION SCHEDULE

ISSUE	DESCRIPTION	DRAWN	DATE
A	CONTRACT PLAN	DC	25/02/14
A-1	AMENDED CONTRACT PLAN	DC	10/03/14
B	DA PLANS	AS	13/05/14
B-1	PLAN AMENDMENTS	AS	15/08/14
B-2	WINDOW AMENDMENTS	AS	20.08.14
-	-	-	-


JOB No:
003535
 DATE:
 25/02/14
 LGA:
 PENRITH
 DESCRIPTION:
 ABODE 27
 CODE:
 WH-ABOD27D CL RH

DRAWN:
 DC
 DATE:
 25/02/14
 SITE CLASSIFICATION:
 'M' CLASS (subject to borehole report)
 FACADE:
 Classic
 SHEET:
8




METRO
 COLLECTION
 by Wisdom


Ph: 4647 1200
 Fax: 4647 1233
 www.wisdomhomes.com.au
 *COPYRIGHT OF PLANS AND DOCUMENTATION REMAIN THE EXCLUSIVE PROPERTY OF WISDOM PROPERTIES GROUP PTY LTD T/A WISDOM HOMES. BUILDERS LIC. No 131951C.

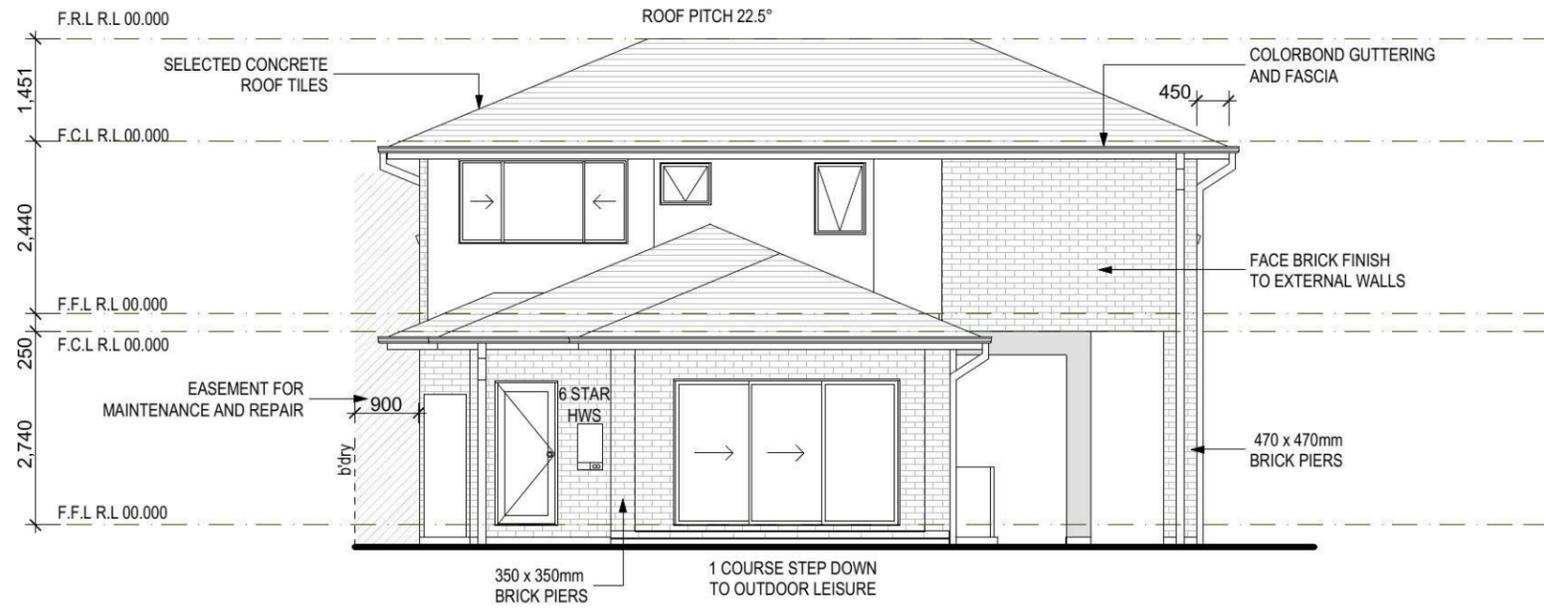

NOTE:
 OPENABLE TO BE IN ACCORDANCE WITH CLAUSE 3.9.2.5 OF THE BCA 2013 VOL. 2 -
 FIRST FLOOR WINDOWS TO BE RESTRICTED TO OPEN A MAX. OF 125mm IF SILL HEIGHT IS LOWER THAN 1700mm ABOVE A FLOOR LEVEL.

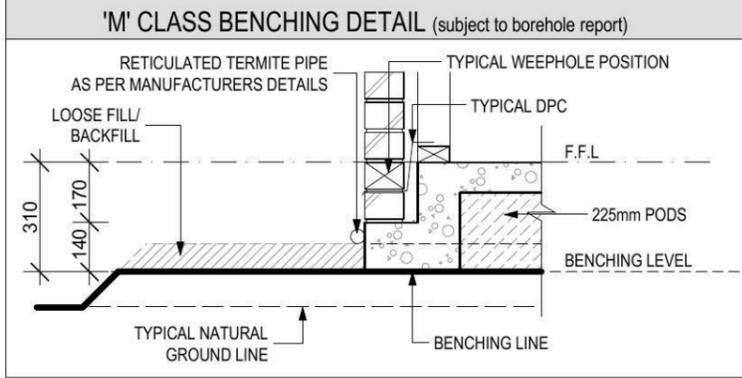

REAR/NORTH ELEVATION
 1:100

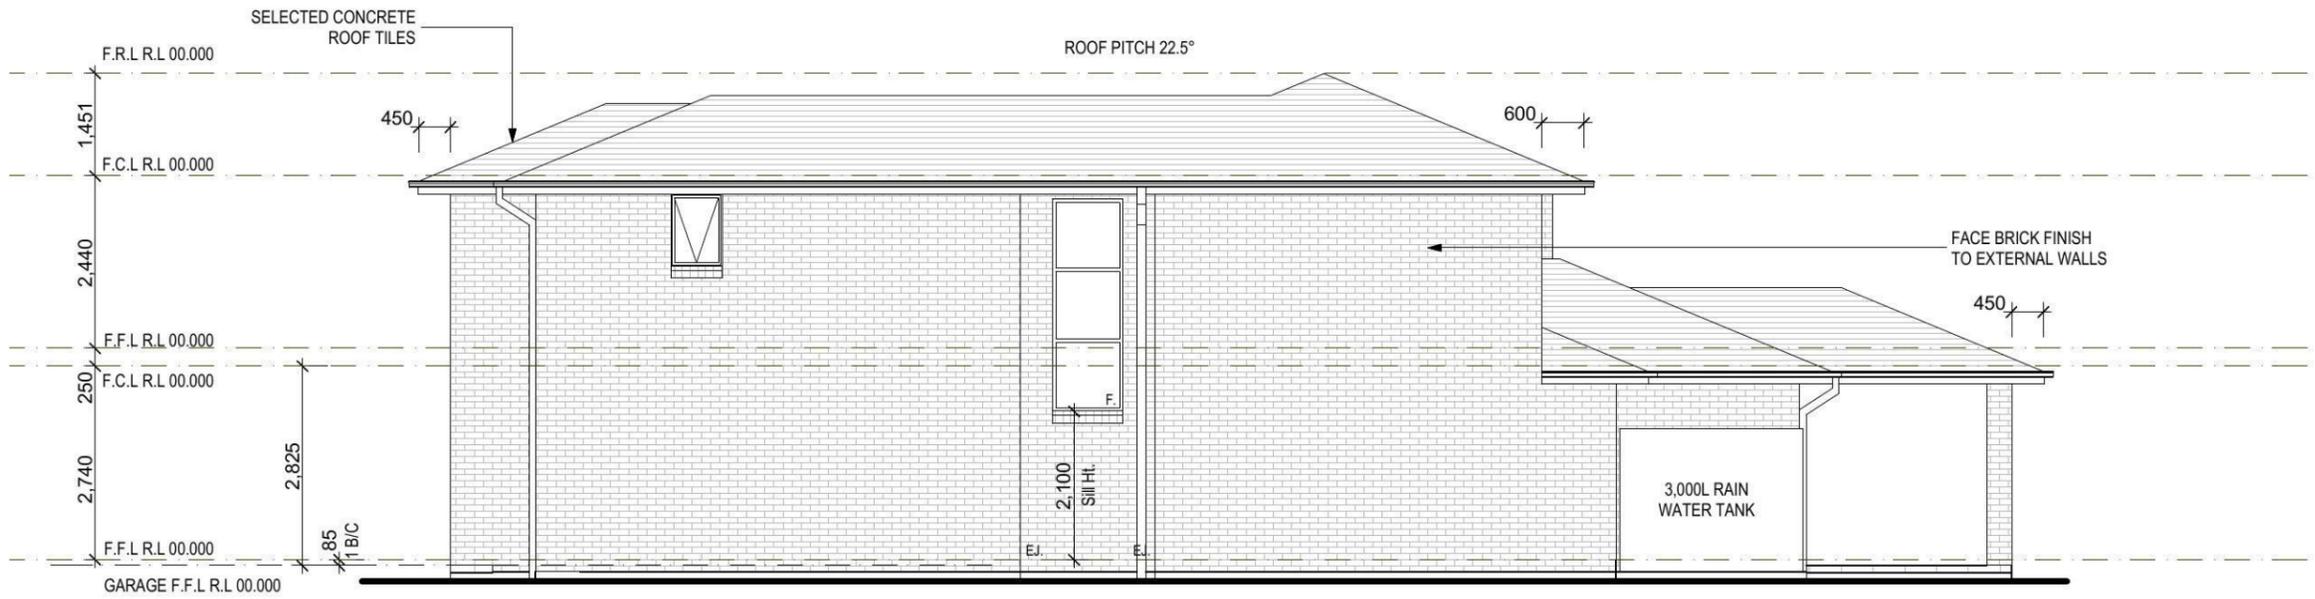

RIGHT/EAST ELEVATION
 1:100

NOTES:
 *REFER TO ENGINEERS DETAILS FOR ALL EXPANSION JOINT LOCATIONS.
 *REFER TO ENGINEERS DETAILS FOR ALL STEEL BEAM AND FLOOR JOIST LOCATIONS AND DIRECTIONS.
 *REFER TO TRUSS MANUFACTURERS DETAILS FOR ALL FLOOR JOIST SIZES AND DIRECTIONS.
 *REFER TO A/C DETAILS FOR A/C DUCT POSITIONS.
 *A/C DUCT LOCATIONS MAY NEED TO CHANGE DUE TO CONSTRUCTION REQUIREMENTS (JOIST LOCATION, STRUCTURAL BEAMS ETC).
 *FLOOR FINISHES AS SELECTED AS PER TENDER.


 Ph: 4647 1200
 Fax: 4647 1233
 www.wisdomhomes.com.au
*COPYRIGHT OF PLANS AND DOCUMENTATION REMAIN THE EXCLUSIVE PROPERTY OF WISDOM PROPERTIES GROUP PTY LTD T/A WISDOM HOMES. BUILDERS LIC. No 131951C.

PROJECT:
 PROPOSED TWO-STOREY BRICK VENEER DWELLING
 ADDRESS:
 Lot 2360 William Hart Crescent
 Thornton Estate, Penrith
 CLIENT:
 Mr Y. SHI & Mrs J. Y. LIN
 LODGEMENT:
 D.A/C.C
 EXHAUST FAN
 SMOKE DETECTOR. AS 3786-1993

NOTES: BOUNDARY SETBACKS MUST BE VERIFIED BY A REGISTERED SURVEYOR BEFORE COMMENCEMENT OF ANY BUILDING WORK. ALL WORK TO BE CARRIED OUT IN ACCORDANCE WITH THESE DRAWINGS, COUNCIL REQUIREMENTS, RELEVANT CODES & STANDARDS. LEVELS SHOWN ARE BASED ON CONTOUR SURVEY PREPARED BY A REGISTERED SURVEYOR. DRAWINGS ARE TO BE READ IN CONJUNCTION WITH SPECIFICATIONS PROVIDED & ENGINEERS DETAILS. WHERE ENGINEERS STRUCTURAL DRAWINGS ARE REQUIRED THE ENGINEERS PLAN WILL TAKE PREFERENCE TO THESE DRAWINGS. IN THE EVENT OF ANY ALTERATIONS OR DISCREPANCIES, NOTIFY WISDOM HOMES IMMEDIATELY. FIGURED DIMENSIONS TO BE READ IN PREFERENCE TO SCALING & TO BE CHECKED & VERIFIED BEFORE WORK IS COMMENCED.


REVISION SCHEDULE			
ISSUE	DESCRIPTION	DRAWN	DATE
A	CONTRACT PLAN	DC	25/02/14
A-1	AMENDED CONTRACT PLAN	DC	10/03/14
B	DA PLANS	AS	13/05/14
B-1	PLAN AMENDMENTS	AS	15/08/14
B-2	WINDOW AMENDMENTS	AS	20.08.14
-	-	-	-

JOB No:
003535
 DATE:
 25/02/14
 LGA:
 PENRITH
 DESCRIPTION:
 ABODE 27
 CODE:
 WH-ABOD27D CL RH

DRAWN:
 DC
 DATE:
 25/02/14
 SITE CLASSIFICATION:
 'M' CLASS (subject to borehole report)
 FACADE:
 Classic
 SHEET:
9

Window Schedule									
Window No.	Type	Window Size		Plan View	Elev. View	Glazing	Frame & Reveal	Flyscreens	Others
		Height	Width						
W1	AA2314T Special	2,040	1,440			Single Clear	240mm Brick veneer	-	-
W2	AF3010 Special	3,000	1,000			Single Clear	240mm Brick veneer	-	-
W3	AS2027T Special	2,042	2,750			Single Clear	240mm Brick veneer	-	-
W4	AS2018T	2,042	1,791			Single Clear	240mm Brick veneer	-	-
W5	AS2018T	2,042	1,791			Single Clear	240mm Brick veneer	-	-
W6	AS2015T	2,042	1,500			Single Clear	240mm Brick veneer	-	-
W7	AAAF2023T Special	2,042	2,330			Single Clear	240mm Brick veneer	-	-
W8	AF2003 Special	2,042	300			Single Clear	90mm TF	-	-
W9	AF2003 Special	2,042	300			Single Clear	90mm TF	-	-
W10	AA1007	1,020	724			Single Obs.	240mm Brick veneer	-	-
W11	AS1224	1,191	2,391			Single Clear	90mm TF	-	-
W12	AA0607	600	724			Single Obsc.	90mm TF	-	-
W13	AA1007	1,020	724			Single Obsc.	90mm TF	-	-
W14	AA1022	1,020	2,153			Single Clear	240mm Brick veneer	-	-
W15	AA1022	1,020	2,153			Single Clear	240mm Brick veneer	-	-
W16	AA1226	1,191	2,630			Single Clear	240mm Brick veneer	-	-
W17	AS1218	1,191	1,791			Single Clear	240mm Brick veneer	-	-

Door Schedule									
Door No.	Type	Door Size		Plan View	Elev. View	Glazing	Frame & Reveal	Flyscreens	Others
		Height	Width						
D1	MEF5	2,040	820			-	240mm Brick veneer	-	-
D2	TSD2032	2,065	2,652			Single Clear	240mm Brick veneer	-	-
D3	TXD2027	2,065	2,685			Single Clear	240mm Brick veneer	-	-
D4	TSD2032	2,065	3,195			Single Clear	240mm Brick veneer	-	-
D5	MEF5	2,040	820			-	240mm Brick veneer	-	-
D6	Int. 820mm hung door	2,040	820			-	90mm TF	-	-
D7	Int. 720mm hung door	2,040	720			-	90mm TF	-	-
D8	Int. 720mm hung door	2,040	1,040			-	90mm TF	-	-
D9	Int. 820mm hung door	2,040	820			-	90mm TF	-	-
D10	TXD2015	2,065	1,500			-	240mm Brick veneer	-	-
D11	Int. 820mm cavity sliding door	2,040	820			-	90mm TF	-	-
D12	Int. 820mm hung door	2,040	820			-	70mm TF	-	-
D13	Int. 820mm hung door	2,040	820			-	70mm TF	-	-
D14	Int. 820mm hung door	2,040	820			-	70mm TF	-	-
D15	Int. 770mm hung door	2,040	770			-	70mm TF	-	Lift-off hinges
D16	Int. 820mm hung door	2,040	820			-	70mm TF	-	-
D17	Int. 820mm hung door	2,040	820			-	70mm TF	-	-

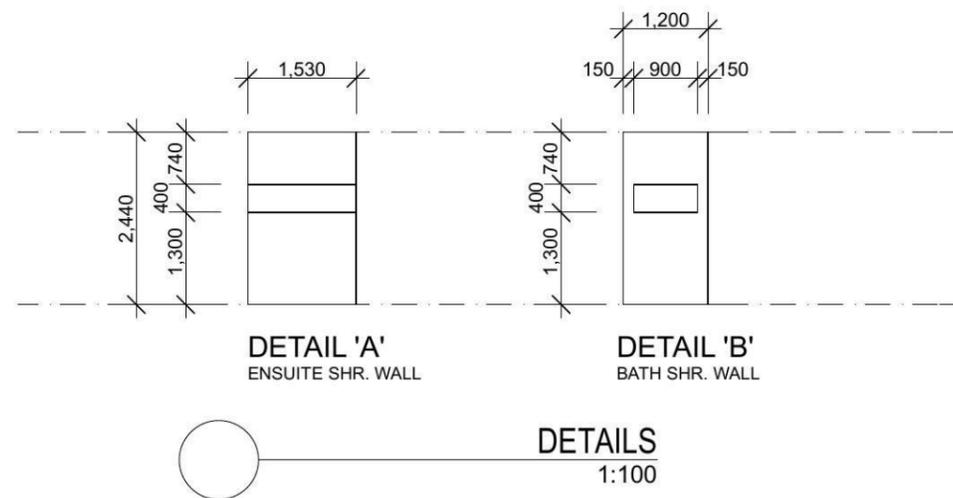

NOTES:
 *REFER TO ENGINEERS DETAILS FOR ALL EXPANSION JOINT LOCATIONS.
 *REFER TO ENGINEERS DETAILS FOR ALL STEEL BEAM AND FLOOR JOIST LOCATIONS AND DIRECTIONS.
 *REFER TO TRUSS MANUFACTURERS DETAILS FOR ALL FLOOR JOIST SIZES AND DIRECTIONS.
 *REFER TO A/C DETAILS FOR A/C DUCT POSITIONS.
 *A/C DUCT LOCATIONS MAY NEED TO CHANGE DUE TO CONSTRUCTION REQUIREMENTS (JOIST LOCATION, STRUCTURAL BEAMS ETC).
 *FLOOR FINISHES AS SELECTED AS PER TENDER.

Ph: 4647 1200
 Fax: 4647 1233
 www.wisdomhomes.com.au

*COPYRIGHT OF PLANS AND DOCUMENTATION REMAIN THE EXCLUSIVE PROPERTY OF WISDOM PROPERTIES GROUP PTY LTD T/A WISDOM HOMES. BUILDERS LIC. No 131951C.

PROJECT:
 PROPOSED TWO-STOREY BRICK VENEER DWELLING

ADDRESS:
 Lot 2360 William Hart Crescent
 Thornton Estate, Penrith

CLIENT:
 Mr Y. SHI & Mrs J. Y. LIN

LOGGEMENT:
 D.A/C.C

⊗ EXHAUST FAN
 ⊗ SMOKE DETECTOR. AS 3786-1993

NOTES: BOUNDARY SETBACKS MUST BE VERIFIED BY A REGISTERED SURVEYOR BEFORE COMMENCEMENT OF ANY BUILDING WORK. ALL WORK TO BE CARRIED OUT IN ACCORDANCE WITH THESE DRAWINGS, COUNCIL REQUIREMENTS, RELEVANT CODES & STANDARDS. LEVELS SHOWN ARE BASED ON CONTOUR SURVEY PREPARED BY A REGISTERED SURVEYOR. DRAWINGS ARE TO BE READ IN CONJUNCTION WITH SPECIFICATIONS PROVIDED & ENGINEERS DETAILS. WHERE ENGINEERS STRUCTURAL DRAWINGS ARE REQUIRED THE ENGINEERS PLAN WILL TAKE PREFERENCE TO THESE DRAWINGS. IN THE EVENT OF ANY ALTERATIONS OR DISCREPANCIES, NOTIFY WISDOM HOMES IMMEDIATELY. FIGURED DIMENSIONS TO BE READ IN PREFERENCE TO SCALING & TO BE CHECKED & VERIFIED BEFORE WORK IS COMMENCED.

REVISION SCHEDULE			
ISSUE	DESCRIPTION	DRAWN	DATE
A	CONTRACT PLAN	DC	25/02/14
A-1	AMENDED CONTRACT PLAN	DC	10/03/14
B	DA PLANS	AS	13/05/14
B-1	PLAN AMENDMENTS	AS	15/08/14
B-2	WINDOW AMENDMENTS	AS	20.08.14
-	-	-	-

JOB No:
003535

LGA:
 PENRITH

DESCRIPTION:
 ABODE 27

CODE:
 WH-ABOD27D CL RH


DRAWN:
 DC

DATE:
 25/02/14


SITE CLASSIFICATION:
 M' CLASS (subject to borehole report)

FACADE:
 Classic


SHEET:
11

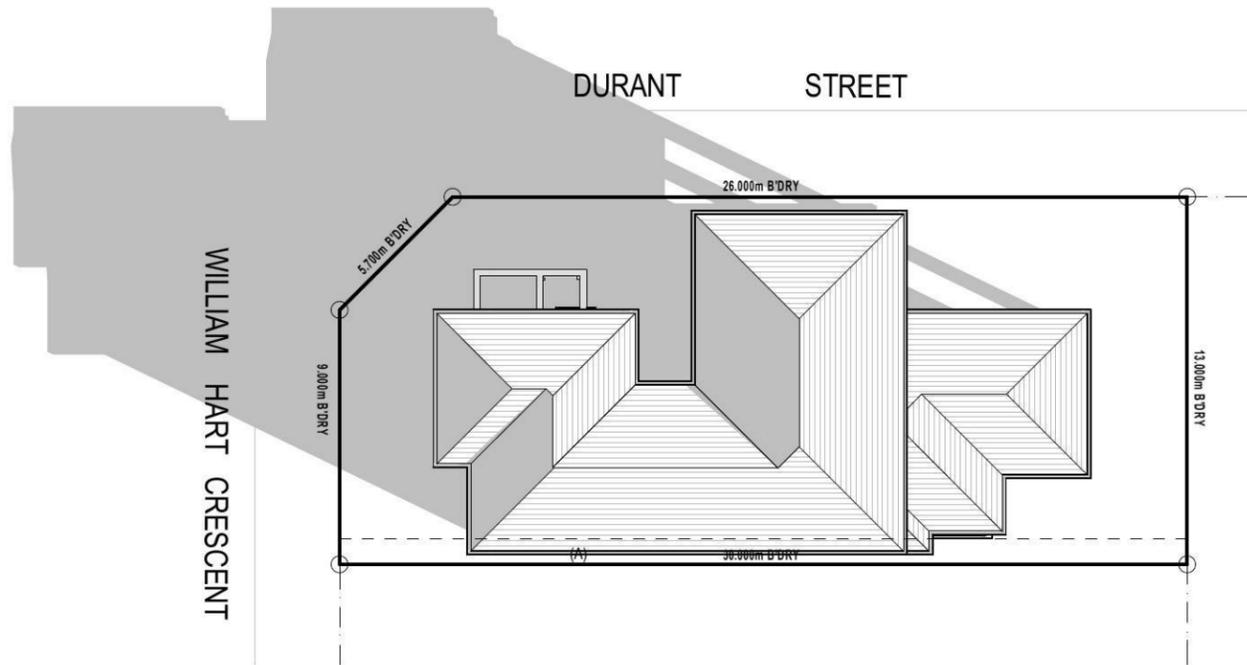

SHADOW PROJECTION 9AM
1:250

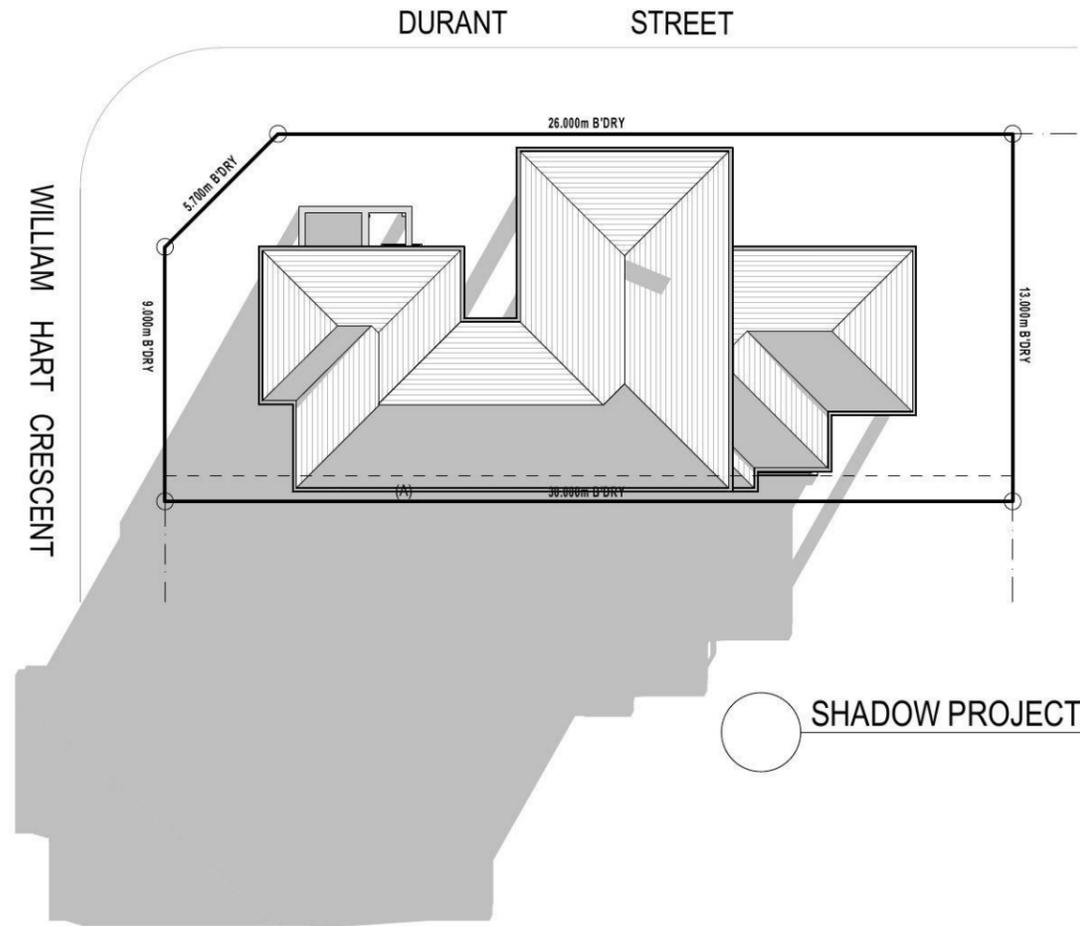

SHADOW PROJECTION 3PM
1:250

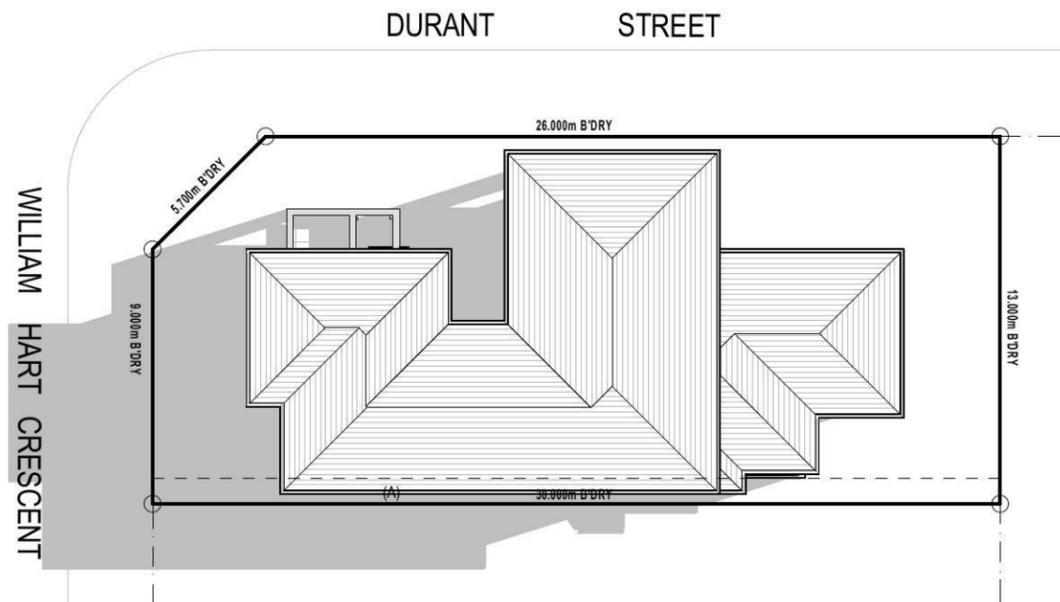

SHADOW PROJECTION 12PM
1:250

SHADOW PROJECTIONS 21st JUNE

NOTES:
 *REFER TO ENGINEERS DETAILS FOR ALL EXPANSION JOINT LOCATIONS.
 *REFER TO ENGINEERS DETAILS FOR ALL STEEL BEAM AND FLOOR JOIST LOCATIONS AND DIRECTIONS.
 *REFER TO TRUSS MANUFACTURERS DETAILS FOR ALL FLOOR JOIST SIZES AND DIRECTIONS.
 *REFER TO A/C DETAILS FOR A/C DUCT POSITIONS.
 *A/C DUCT LOCATIONS MAY NEED TO CHANGE DUE TO CONSTRUCTION REQUIREMENTS (JOIST LOCATION, STRUCTURAL BEAMS ETC).
 *FLOOR FINISHES AS SELECTED AS PER TENDER.

Ph: 4647 1200
 Fax: 4647 1233
 www.wisdomhomes.com.au

*COPYRIGHT OF PLANS AND DOCUMENTATION REMAIN THE EXCLUSIVE PROPERTY OF WISDOM PROPERTIES GROUP PTY LTD T/A WISDOM HOMES. BUILDERS LIC. No 131951C.

PROJECT:
 PROPOSED TWO-STOREY BRICK VENEER DWELLING

ADDRESS:
 Lot 2360 William Hart Crescent
 Thornton Estate, Penrith

CLIENT:
 Mr Y. SHI & Mrs J. Y. LIN

LODGE MENT:
 D.A/C.C

⊗ EXHAUST FAN
 ☉ SMOKE DETECTOR. AS 3786-1993

NOTES: BOUNDARY SETBACKS MUST BE VERIFIED BY A REGISTERED SURVEYOR BEFORE COMMENCEMENT OF ANY BUILDING WORK. ALL WORK TO BE CARRIED OUT IN ACCORDANCE WITH THESE DRAWINGS, COUNCIL REQUIREMENTS, RELEVANT CODES & STANDARDS. LEVELS SHOWN ARE BASED ON CONTOUR SURVEY PREPARED BY A REGISTERED SURVEYOR. DRAWINGS ARE TO BE READ IN CONJUNCTION WITH SPECIFICATIONS PROVIDED & ENGINEERS DETAILS. WHERE ENGINEERS STRUCTURAL DRAWINGS ARE REQUIRED THE ENGINEERS PLAN WILL TAKE PREFERENCE TO THESE DRAWINGS. IN THE EVENT OF ANY ALTERATIONS OR DISCREPANCIES, NOTIFY WISDOM HOMES IMMEDIATELY. FIGURED DIMENSIONS TO BE READ IN PREFERENCE TO SCALING & TO BE CHECKED & VERIFIED BEFORE WORK IS COMMENCED.

REVISION SCHEDULE			
ISSUE	DESCRIPTION	DRAWN	DATE
A	CONTRACT PLAN	DC	25/02/14
A-1	AMENDED CONTRACT PLAN	DC	10/03/14
B	DA PLANS	AS	13/05/14
B-1	PLAN AMENDMENTS	AS	15/08/14
B-2	WINDOW AMENDMENTS	AS	20.08.14
-	-	-	-

JOB No:
003535

LGA:
PENRITH

DESCRIPTION:
ABODE 27

CODE:
WH-ABOD27D CL RH

DRAWN:
DC

DATE:
25/02/14

SITE CLASSIFICATION:
M' CLASS (subject to borehole report)

FACADE:
Classic

SHEET:
16